



KEYNOTES

- 4 ALCOHOL LICENSE NUMBER ; OWNER FURNISHED, OWNER INSTALLED.
- 30 PREFINISHED METAL COPING.
- 51 THORNTONS SIGNAGE BY OTHERS
- 80 BUILDING ADDRESS AND STORE NUMBER LOCATION.
- 100 NICHHA PANEL SYSTEM - STYLE: ILLUMINATION SERIES COLOR: PANTONE RED PMS 186 RED ; OWNER FURNISHED, CONTRACTOR INSTALLED.
- 101 NICHHA PANEL SYSTEM - STYLE: PLYMOUTH BRICK COLOR: CRIMSON ; OWNER FURNISHED, CONTRACTOR INSTALLED.
- 103 NICHHA SYNTHETIC STONE SYSTEM - STYLE: KURASTONE DESERT ; OWNER FURNISHED, CONTRACTOR INSTALLED.
- 104 NICHHA FLASHING AT WATER TABLE AND BOTTOM EDGE OF LOWER WALL PANELS, TYP. ENTIRE PERIMETER, OWNER FURNISHED, OWNER INSTALLED.
- 105 NICHHA SILL-CHISELED SYSTEM- COLOR: MATCH KURASTONE ; OWNER FURNISHED, CONTRACTOR INSTALLED.
- 106 TRELIS - COLOR: BLACK ; OWNER FURNISHED AND CONTRACTOR INSTALLED. GC TO PROVIDE BLOCKING AS REQUIRED.
- 107 TRELIS (CANOPY) - COLOR: BLACK ; OWNER FURNISHED AND CONTRACTOR INSTALLED. GC TO PROVIDE BLOCKING AS REQUIRED.
- 108 LOUVER SYSTEM - COLOR: PANTONE 860C PEWTER ; OWNER FURNISHED AND CONTRACTOR INSTALLED. GC TO PROVIDE BLOCKING AS REQUIRED.
- 111 PREFINISHED METAL COPING - COLOR: BLACK ; CONTRACTOR FURNISHED, CONTRACTOR INSTALLED.
- 112 SCHEDULED DOOR AND FRAME - REFER SHEET A6.1.
- 116 EXTERIOR LIGHT FIXTURE - REFER TO ELECTRICAL DRAWINGS.
- 129 GAS SERVICE, PAINT CONNECTING PIPES BLACK. REFER TO PLUMBING DRAWINGS.
- 154 WINDOW FILM, FURNISHED & INSTALLED BY OWNER
- 156 THIN CAULK LINE

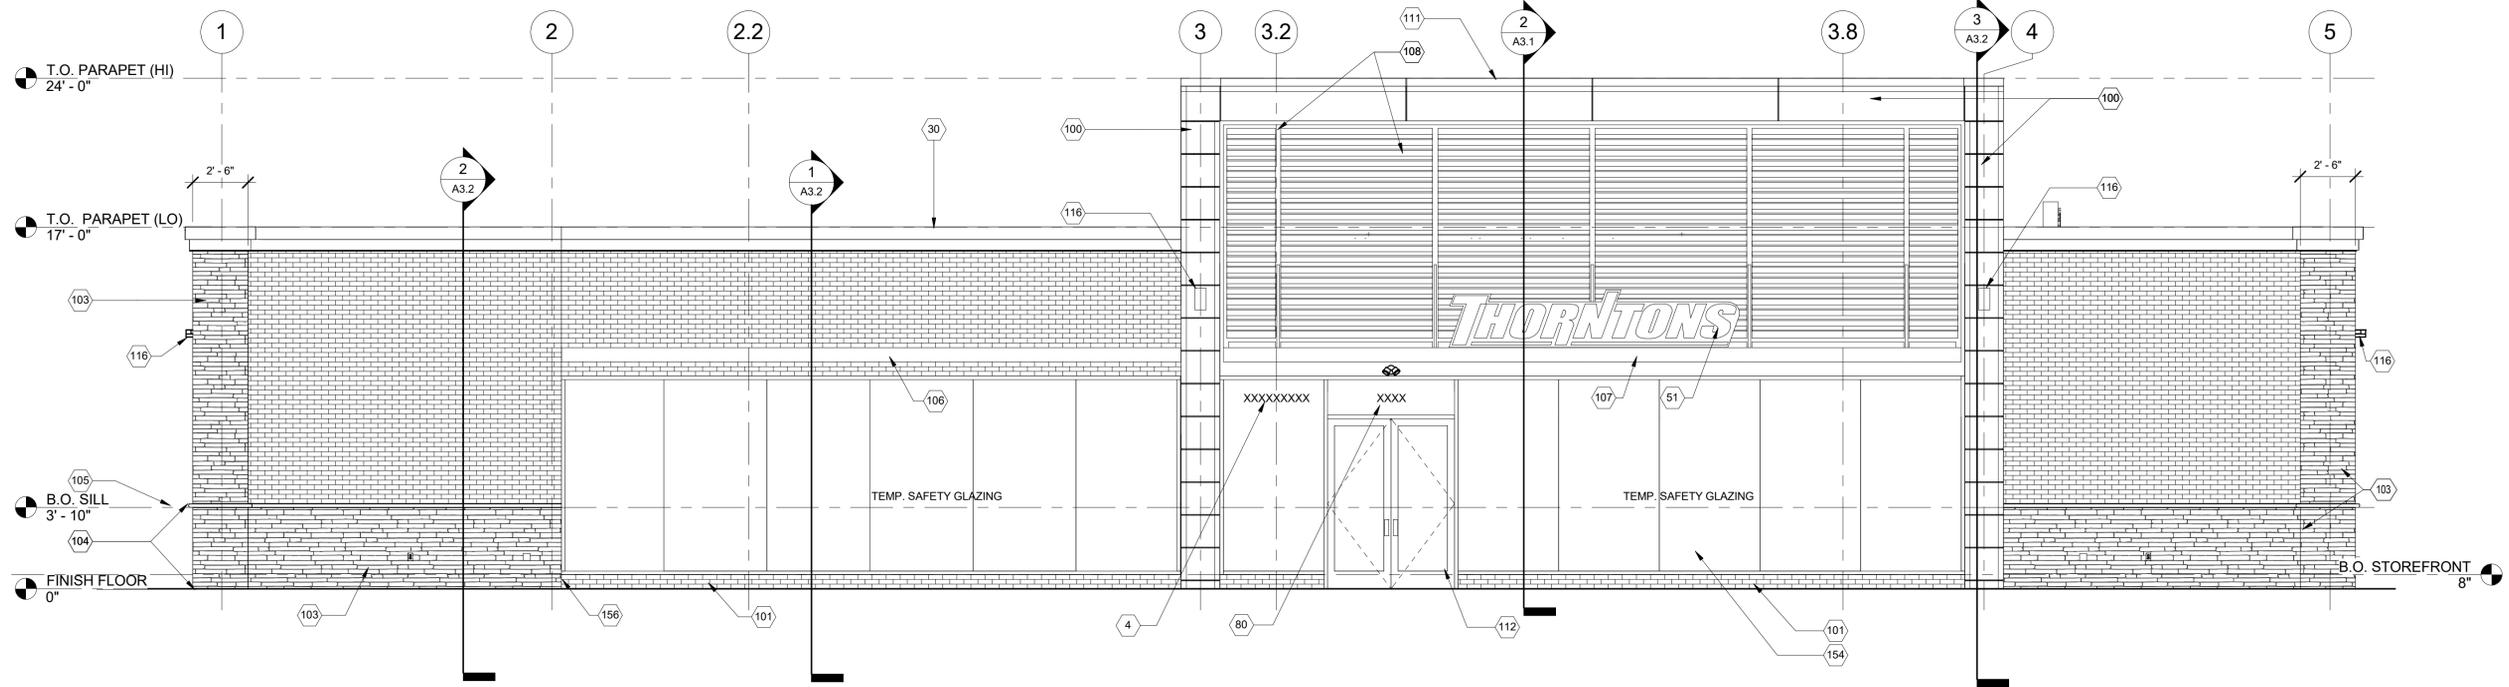


2 Front with Stone Columns

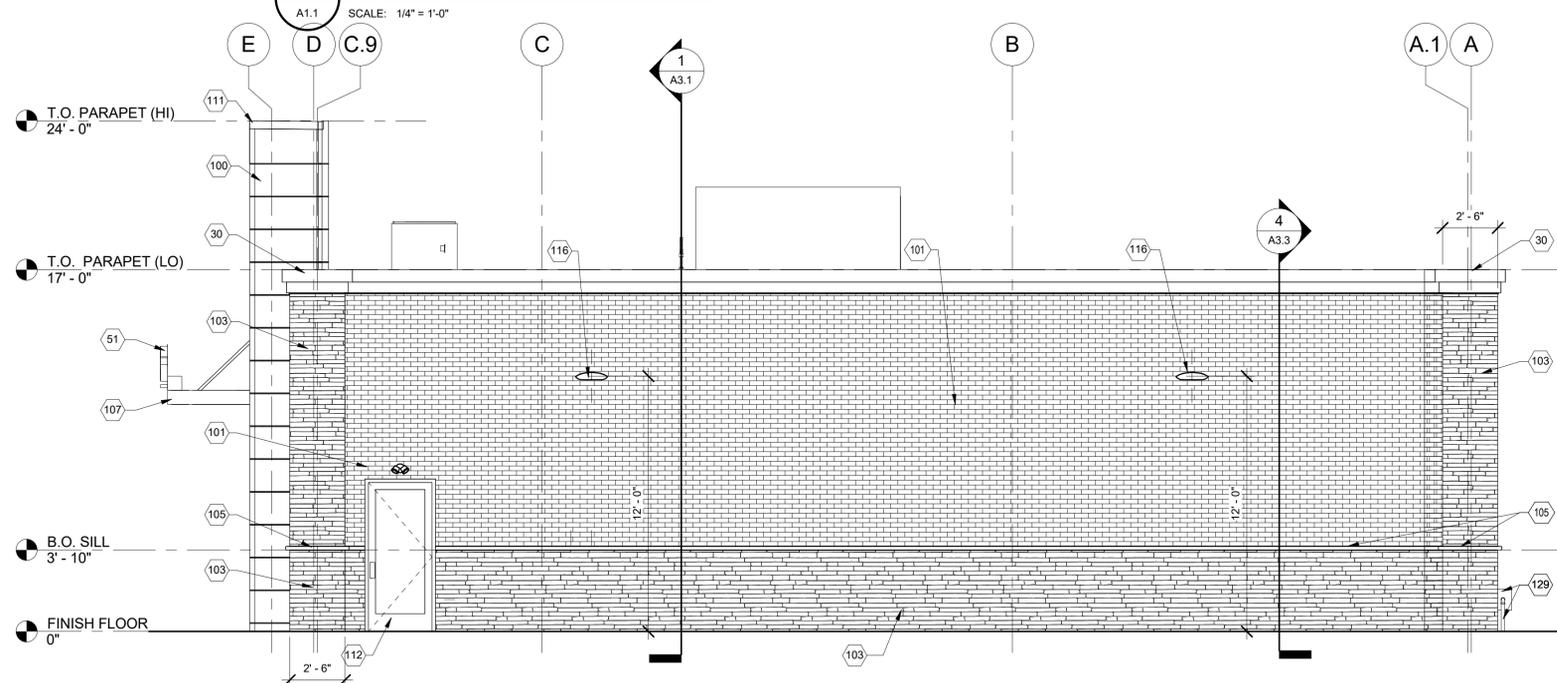

3 Side Exterior Elevation

A1.1 SCALE: 1/4" = 1'-0"

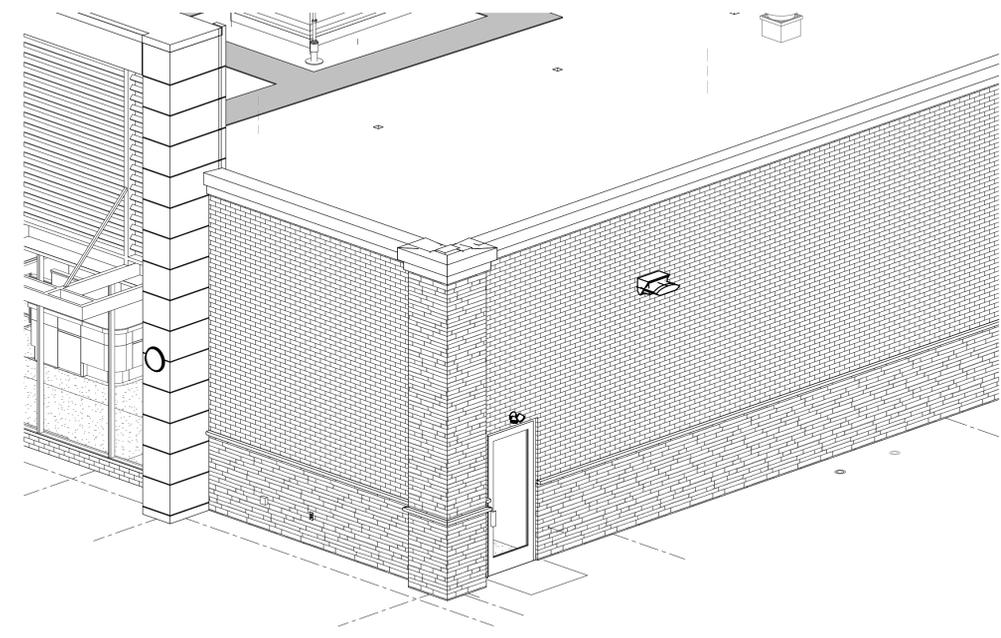

1 3D View of Corner Column

SCALE:

[smart design]SM
Luckett & Farley
 737 South Third Street, Louisville, Kentucky 40202-2100
 502-582-4181 502-587-0488 Fax www.luckettfarley.com
 Master Planning | Architecture | Engineering | Interior Design

THORNTONS P1709
 BOLING BROOK DRIVE at
 COLLET FOUNTAIN
 ROMEVILLE, IL 60446

THORNTONS

#	Description	Date

FORM NO.	2017.197
MADE BY	Author
CHECKED BY	Checker
DATE	Issue Date


Illustration

DRAWING NO.	C1.7
BID FILE	

NOT FOR CONSTRUCTION
 SCALE SHOWN TO ENSURE REPRODUCTION ACCURACY

EXTERIOR ELEVATION KEYNOTE


- 801 NICHIIA PANEL SYSTEM - STYLE: ILLUMINATION SERIES COLOR: PANTONE RED PMS 186 RED ; CONTRACTOR FURNISHED, CONTRACTOR INSTALLED
- 802 NICHIIA PANEL SYSTEM - STYLE: PLYMOTH BRICK COLOR: CRIMSON ; CONTRACTOR FURNISHED, CONTRACTOR INSTALLED
- 803 NICHIIA PANEL SYSTEM - STYLE: ILLUMINATION SERIES COLOR: BENJAMIN MOORE DEEP SPACE 2125-20 ; CONTRACTOR FURNISHED, CONTRACTOR INSTALLED
- 804 NICHIIA SYNTHETIC STONE SYSTEM - STYLE: KURASTONE DESERT ; CONTRACTOR FURNISHED, CONTRACTOR INSTALLED
- 805 ARCHITECTURAL CANOPY AND LOUVER SYSTEM - COLOR: BLACK ; VENDOR FURNISHED, CONTRACTOR INSTALLED
- 806 ARCHITECTURAL CANOPY AND LOUVER SYSTEM - COLOR: PANTONE 8600C PEWTER ; VENDOR FURNISHED, CONTRACTOR INSTALLED
- 807 PREFINISHED METAL COPING - COLOR: BLACK ; CONTRACTOR FURNISHED, CONTRACTOR INSTALLED
- 808 PREFINISHED METAL GUTTER SYSTEM - COLOR: BLACK ; CONTRACTOR FURNISHED, CONTRACTOR INSTALLED
- 809 PREFINISHED METAL DOWNSPOUT SYSTEM, SUPPLY MATCHING RECEIVING BOOT FOR TRANSITION TO UNDERGROUND STORM DRAINAGE - COLOR: BLACK ; CONTRACTOR FURNISHED, CONTRACTOR INSTALLED
- 810 NICHIIA SILL-CHISELED SYSTEM - COLOR: MATCH KURASTONE ; CONTRACTOR FURNISHED, CONTRACTOR INSTALLED
- 811 ROOF ACCESS LADDER SYSTEM - COLOR: BLACK ; CONTRACTOR FURNISHED, CONTRACTOR INSTALLED
- 812 SCHEDULED DOOR AND FRAME - SEE A14.1 SHEET FOR MORE INFORMATION
- 814 LINE OF FOUNDATION BELOW - SEE STRUCTURAL DRAWINGS FOR MORE INFORMATION
- 815 ALCOHOL LICENSE NUMBER ; OWNER FURNISHED, OWNER INSTALLED
- 816 LINE OF ROOF TOP MECHANICAL EQUIPMENT BEYOND - SEE MECHANICAL DRAWINGS FOR MORE INFORMATION
- 817 EXTERIOR LIGHT FIXTURE - VERIFY COLOR WITH OWNER PRIOR TO CONSTRUCTION - SEE ELECTRICAL DRAWINGS FOR MORE INFORMATION
- 818 ELECTRIC POWER OULET - SEE ELECTRICAL DRAWINGS FOR MORE INFORMATION
- 819 FREEZELESS WALL HYDRANT ASSEMBLY - SEE PLUMBING DRAWINGS FOR MORE INFORMATION
- 821 MEMBRANE ROOFING SYSTEM.
- 822 VERIFY FINAL LOCATION OF EMERGENCY GAS SHUT OFF WITH FUEL SYSTEM VENDOR - MOUNTING HEIGHT TO BE 4'-0" ABOVE FINISH GRADE.
- 823 ELECTRIC SERVICE EQUIPMENT, PAINTED:STEALTH GREY - SEE ELECTRICAL DRAWINGS FOR MORE INFORMATION.
- 824 SEE PLUMBING DRAWINGS FOR GAS SERVICE INFORMATION AND REQUIREMENTS.
- 825 BUILDING ADDRESS AND STORE NUMBER LOCATION.
- 826 PANEL SYSTEM VERTICAL EXPANSION JOINT LOCATION - INSTALL PER MANUFACTURER.
- 827 ALUMIUNUM SCREEN WALL SYSTEM - SEE ROOF PLAN FOR MORE INFORMATION.

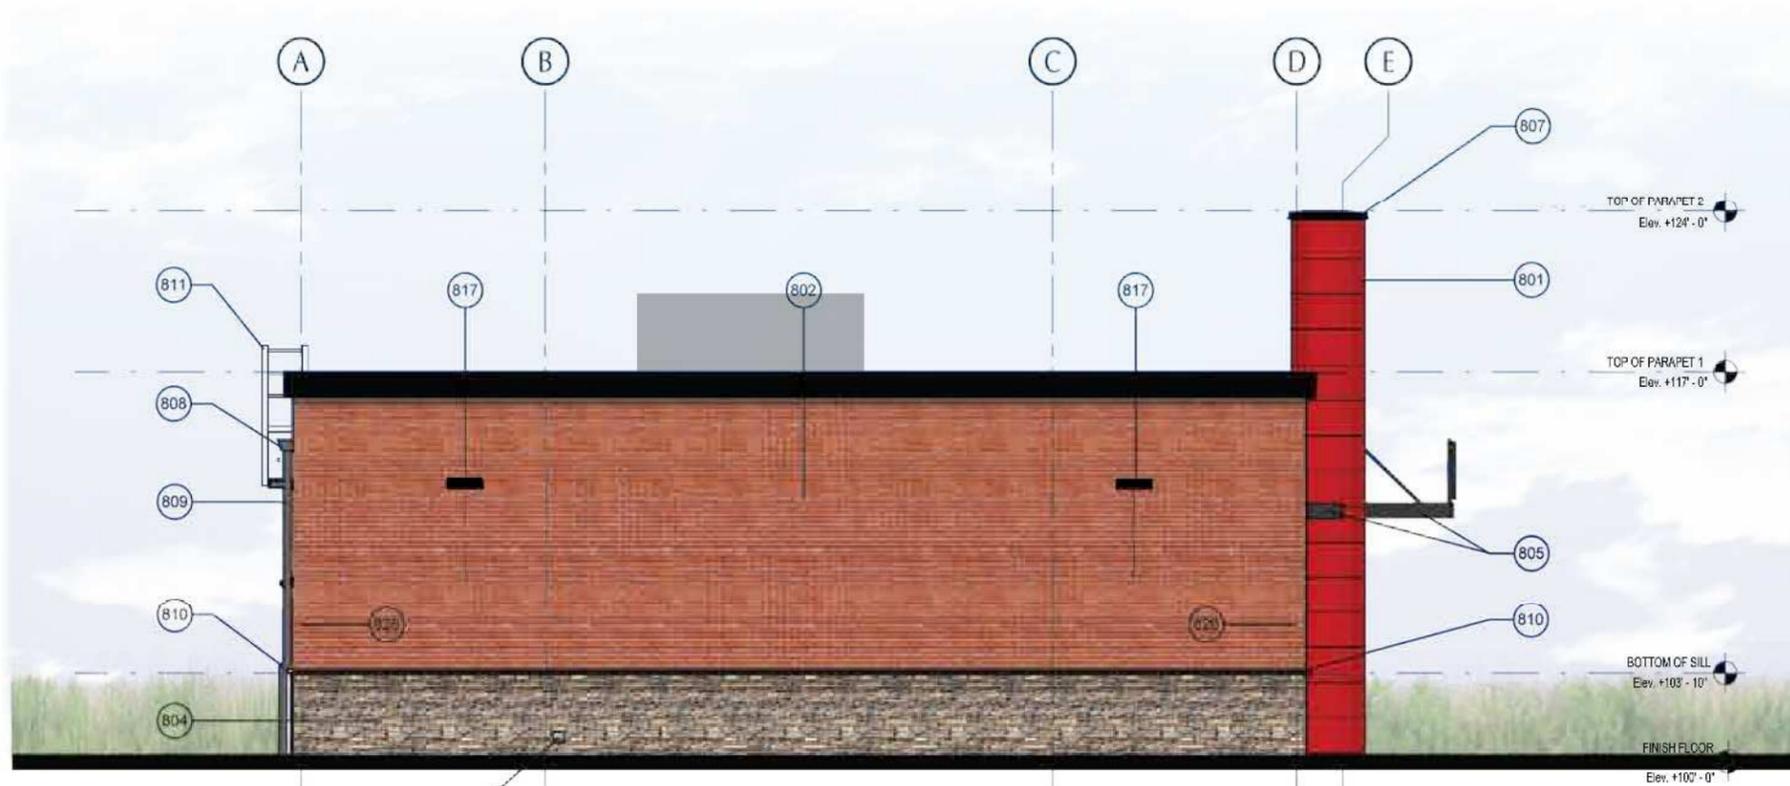

Building left Elevation


EXTERIOR ELEVATION KEYNOTE

- 801 NICHIIA PANEL SYSTEM - STYLE: ILLUMINATION SERIES COLOR: PANTONE RED PMS 186 RED ; CONTRACTOR FURNISHED, CONTRACTOR INSTALLED
- 802 NICHIIA PANEL SYSTEM - STYLE: PLYMOTH BRICK COLOR: CRIMSON ; CONTRACTOR FURNISHED, CONTRACTOR INSTALLED
- 803 NICHIIA PANEL SYSTEM - STYLE: ILLUMINATION SERIES COLOR: BENJAMIN MOORE DEEP SPACE 2125-20 ; CONTRACTOR FURNISHED, CONTRACTOR INSTALLED
- 804 NICHIIA SYNTHETIC STONE SYSTEM - STYLE: KURASTONE DESERT ; CONTRACTOR FURNISHED, CONTRACTOR INSTALLED
- 805 ARCHITECTURAL CANOPY AND LOUVER SYSTEM - COLOR: BLACK ; VENDOR FURNISHED, CONTRACTOR INSTALLED
- 806 ARCHITECTURAL CANOPY AND LOUVER SYSTEM - COLOR: PANTONE 8600C PEWTER ; VENDOR FURNISHED, CONTRACTOR INSTALLED
- 807 PREFINISHED METAL COPING - COLOR: BLACK ; CONTRACTOR FURNISHED, CONTRACTOR INSTALLED
- 808 PREFINISHED METAL GUTTER SYSTEM - COLOR: BLACK ; CONTRACTOR FURNISHED, CONTRACTOR INSTALLED
- 809 PREFINISHED METAL DOWNSPOUT SYSTEM, SUPPLY MATCHING RECEIVING BOOT FOR TRANSITION TO UNDERGROUND STORM DRAINAGE - COLOR: BLACK ; CONTRACTOR FURNISHED, CONTRACTOR INSTALLED
- 810 NICHIIA SILL-CHISELED SYSTEM - COLOR: MATCH KURASTONE ; CONTRACTOR FURNISHED, CONTRACTOR INSTALLED
- 811 ROOF ACCESS LADDER SYSTEM - COLOR: BLACK ; CONTRACTOR FURNISHED, CONTRACTOR INSTALLED
- 812 SCHEDULED DOOR AND FRAME - SEE A14.1 SHEET FOR MORE INFORMATION
- 814 LINE OF FOUNDATION BELOW - SEE STRUCTURAL DRAWINGS FOR MORE INFORMATION
- 815 ALCOHOL LICENSE NUMBER ; OWNER FURNISHED, OWNER INSTALLED
- 816 LINE OF ROOF TOP MECHANICAL EQUIPMENT BEYOND - SEE MECHANICAL DRAWINGS FOR MORE INFORMATION
- 817 EXTERIOR LIGHT FIXTURE - VERIFY COLOR WITH OWNER PRIOR TO CONSTRUCTION - SEE ELECTRICAL DRAWINGS FOR MORE INFORMATION
- 818 ELECTRIC POWER OULET - SEE ELECTRICAL DRAWINGS FOR MORE INFORMATION
- 819 FREEZELESS WALL HYDRANT ASSEMBLY - SEE PLUMBING DRAWINGS FOR MORE INFORMATION
- 821 MEMBRANE ROOFING SYSTEM.
- 822 VERIFY FINAL LOCATION OF EMERGENCY GAS SHUT OFF WITH FUEL SYSTEM VENDOR - MOUNTING HEIGHT TO BE 4'-0" ABOVE FINISH GRADE.
- 823 ELECTRIC SERVICE EQUIPMENT, PAINTED STEALTH GREY - SEE ELECTRICAL DRAWINGS FOR MORE INFORMATION.
- 824 SEE PLUMBING DRAWINGS FOR GAS SERVICE INFORMATION AND REQUIREMENTS.
- 825 BUILDING ADDRESS AND STORE NUMBER LOCATION.
- 826 PANEL SYSTEM VERTICAL EXPANSION JOINT LOCATION - INSTALL PER MANUFACTURER.
- 827 ALUMINUM SCREEN WALL SYSTEM - SEE ROOF PLAN FOR MORE INFORMATION.

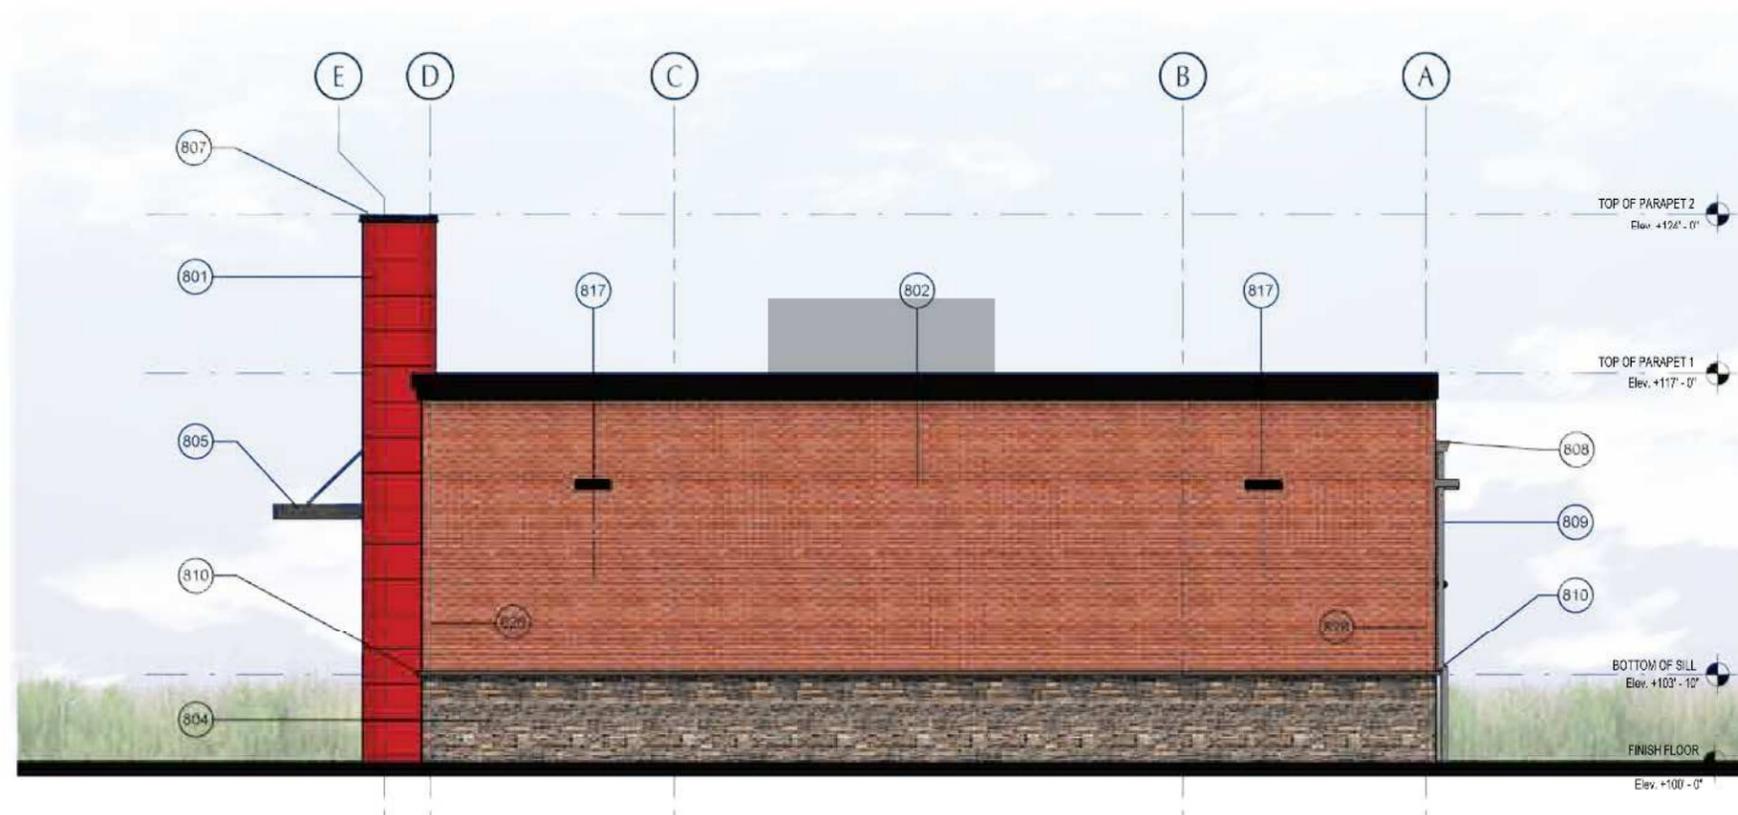







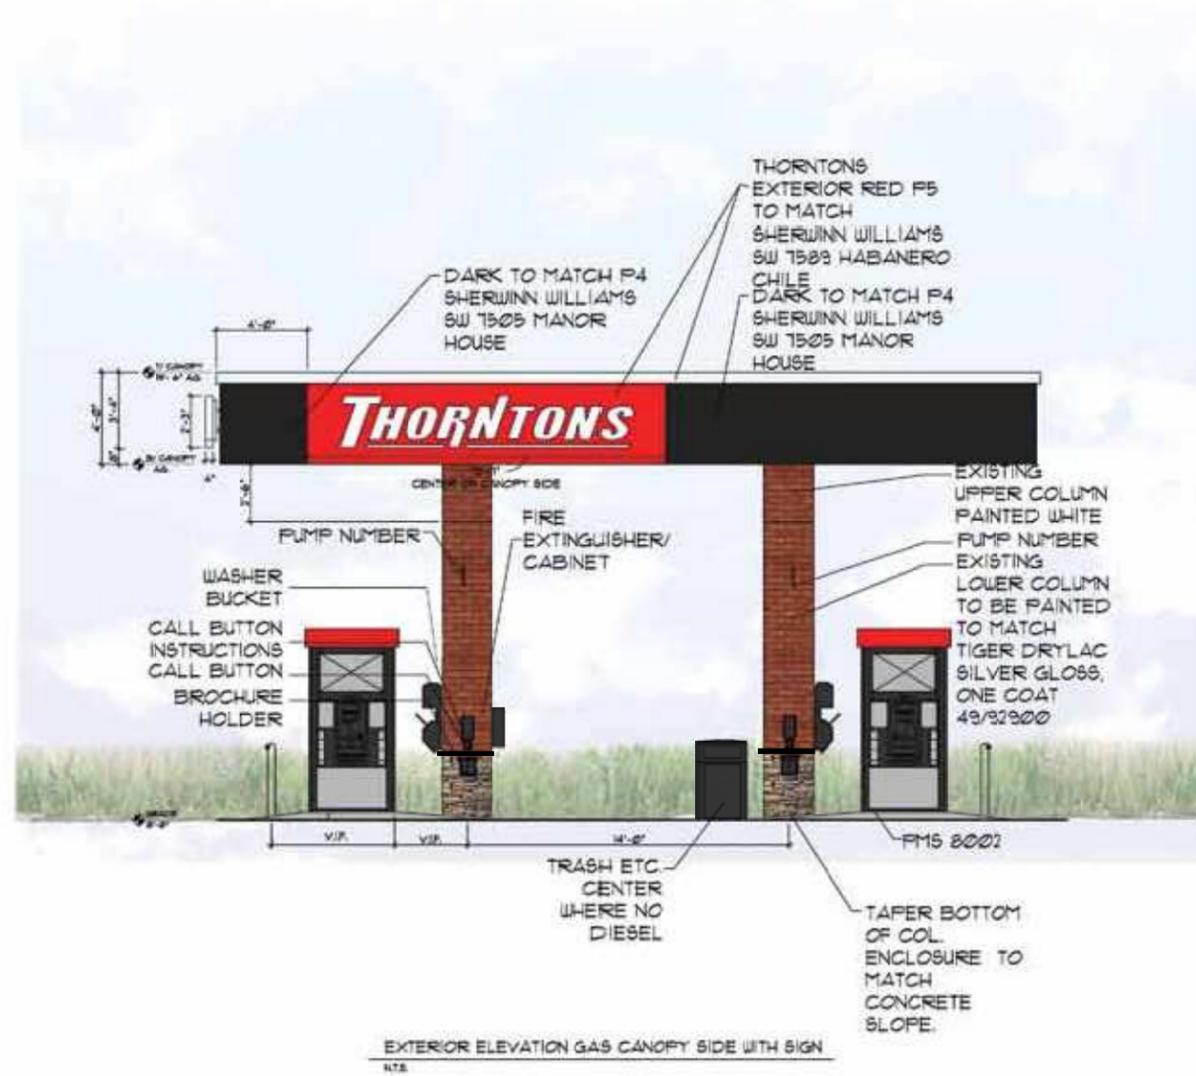



SITE PLAN

Scale: not to scale

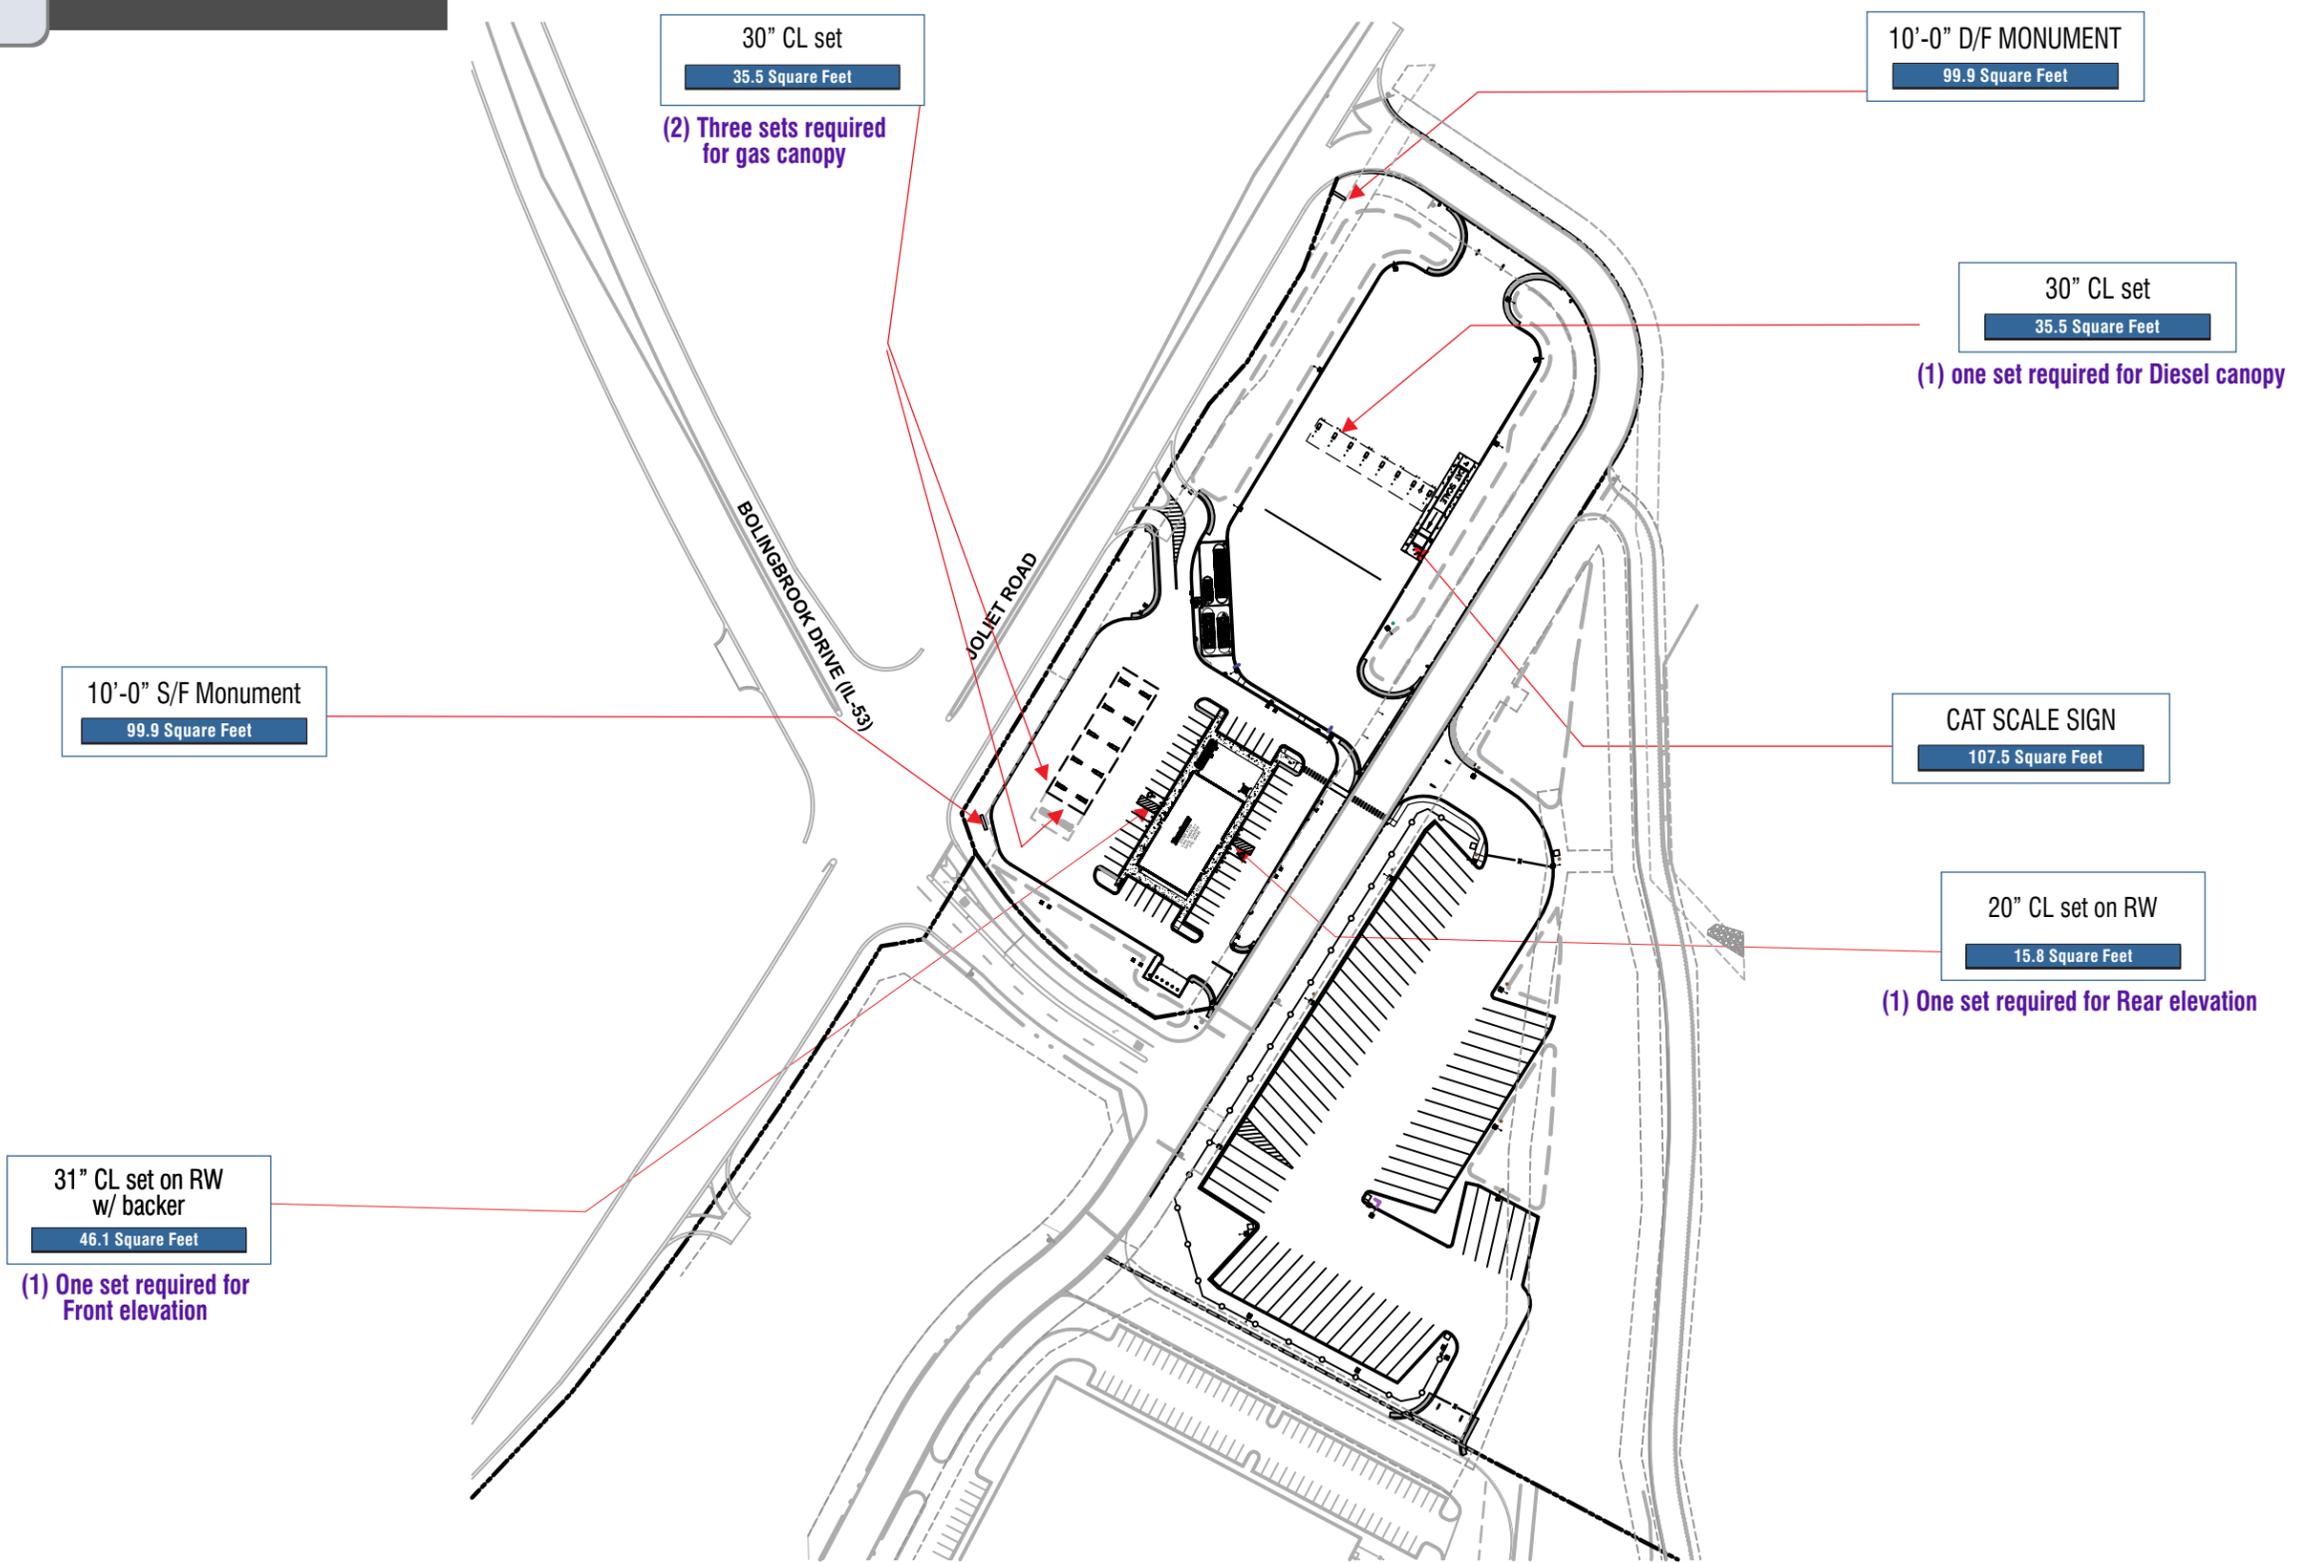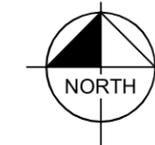

www.mcsign.com

CLIENT: **THORNTONS**
 ADDRESS: STORE #91709
 1101 N. INDEPENDENCE BLVD.
 ROMEOVILLE, IL 60446
 PAGE NO.: 1

TICKET NO.: 439438
 DATE: 1/25/17
 PROJECT MANAGER: PHIL SWAN
 DESIGNER: SI
 ELECTRONIC FILE NAME:
 THORNTONS\2017\IL\P1709 - ROMEOVILLE

REVISION HISTORY:

04/12/17 TB	Put site plan and signs on plan to scale; removed monument; Added new pylons
05/16/17 DN	several revisions
5/17/17 SI	Revised to show CL's on right front of canopy; Added CAT Scale
08/11/17 TB	Revised Hi-Rise pylons to Monuments
9/22/17 SI	Revised to show monuments as 15'-0" OAH
10/2/17 SI	Added 20" letterset to rear elevation 10/31/17 Viv Updated site plan
10/03/17 KW	Revised sq ft - rear letterset
10/10/17 KW	Revised placement & added signage
10/19/17 KW	Revised site plan / placement

CLIENT SIGNATURE:
 APPROVAL DATE:

Corporate Office:
 8959 Tyler Boulevard
 Mentor, Ohio 44060
 440-209-6200
 800-627-4460

334 Industrial Park Road
 Bluefield, Virginia 24605
 877-779-9977

NOTE: PRINTS ARE THE EXCLUSIVE PROPERTY OF "MC SIGN COMPANY". ANY UNAUTHORIZED USE OR DUPLICATION WILL RESULT IN A 20% CHARGE PER OCCURRENCE PER THE VALUE OF THE DISPLAY. MC SIGN CO 1998

BUILDING ELEVATIONS

Scale: 1/8" = 1'-0"

*TYPICAL ELEVATIONS SHOWN FOR VIEWING PURPOSES;
ACTUAL ELEVATIONS TO BE PROVIDED*

SITE SURVEY
REQUIRED PRIOR
TO FINAL PRODUCTION TO
CONFIRM ALL SIZES!



TYPICAL BUILDING FRONT ELEVATION



TYPICAL BUILDING REAR ELEVATION

Partner with the best.



www.mcsign.com

CLIENT:
THORNTONS

ADDRESS:
STORE #91709
1101 N. INDEPENDENCE BLVD.
ROMEDEVILLE, IL 60446

PAGE NO.:
2

TICKET NO.:
439438

PROJECT MANAGER:
PHIL SWAN

ELECTRONIC FILE NAME:
THORNTONS\2017\IL\P1709 - ROMEDEVILLE

DATE:
02/02/17

DESIGNER:
KW

REVISION HISTORY:

10/2/17 SI	Added typ. rear elevation

CLIENT SIGNATURE:

APPROVAL DATE:



Corporate Office:
8959 Tyler Boulevard
Mentor, Ohio 44060
440-209-6200
800-627-4460

334 Industrial Park Road
Bluefield, Virginia 24605
877-779-9977


NOTE: PRINTS ARE THE EXCLUSIVE PROPERTY OF "MC SIGN COMPANY". ANY UNAUTHORIZED USE OR DUPLICATION WILL RESULT IN A 20% CHARGE PER OCCURRENCE PER THE VALUE OF THE DISPLAY. MC SIGN CO 1998

LED ILLUMINATED CHANNEL LETTERS

Scale: 1/2" = 1'-0"

46.1 square feet

31 INCH on backer

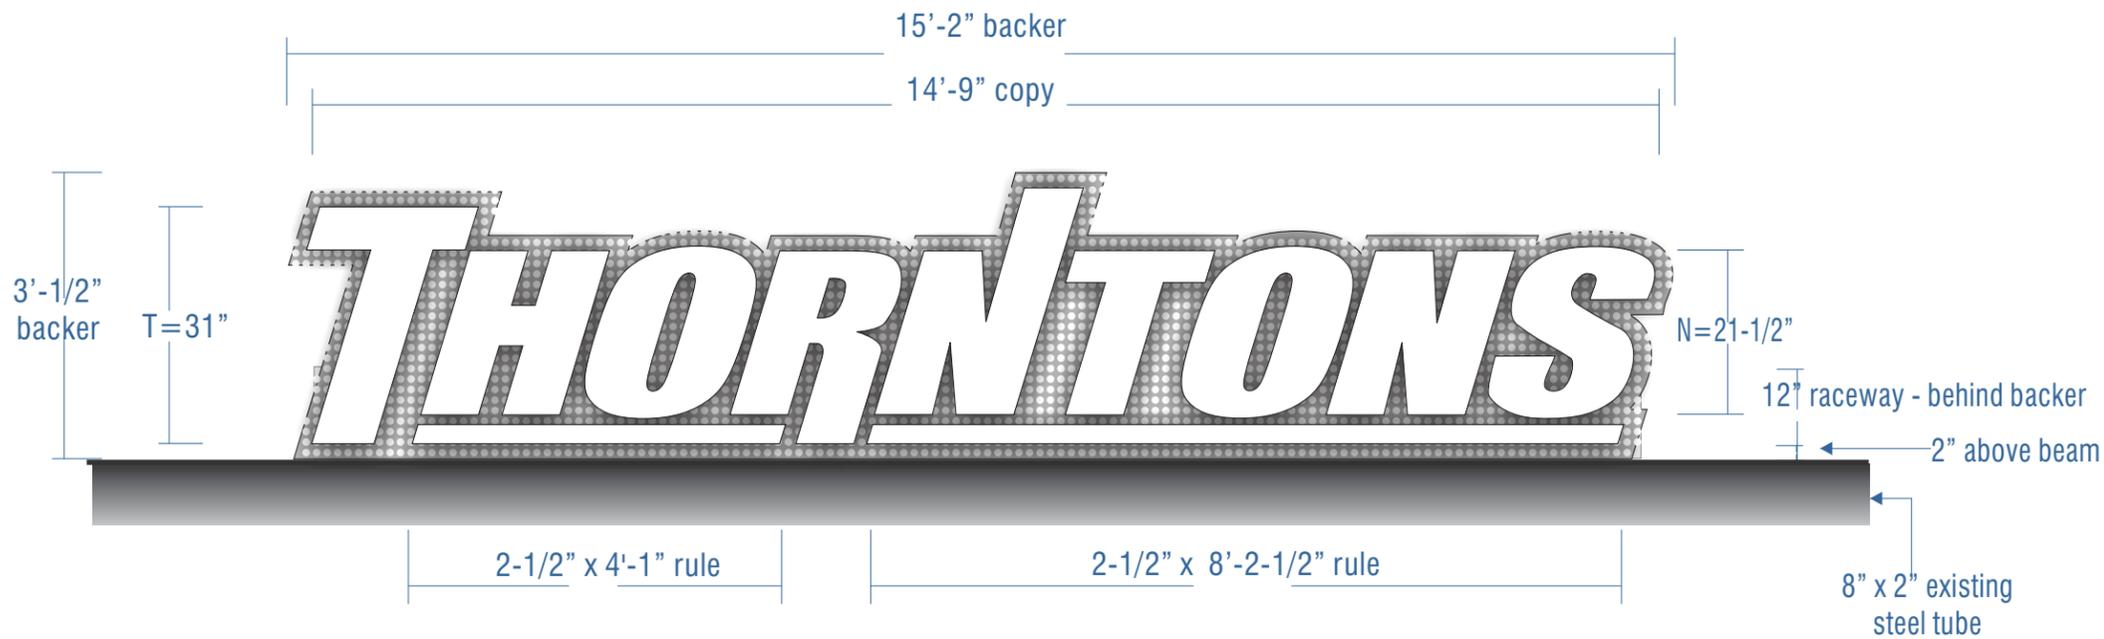


SITE SURVEY
REQUIRED PRIOR
TO FINAL PRODUCTION TO
CONFIRM ALL SIZES!

COLOR MATCHING

-  #7328 white acrylic
-  Raceway - Black
-  Metallic Silver
MP 33172 Silver Surfer Metallic

- FACES:** 3/16" #7328 White acrylic
- TRIMCAP:** 1" White jewelite
- LETTER BACKS:** .063 alum. - prefinish White all sides
- RETURNS:** 5" deep .040 alum. returns painted GG White
- ILLUMINATION:** White LED's as required by manufacturer; Whips to be a minimum of 6'-0" in length
- BACKER:** .080 perforated alum. screen backer; Holes to be .50" diameter and are 11/16" on centers to allow for 48% visibility; Backer painted Metallic Silver front & back; Backer to be mounted behind letters & will help to conceal raceway
- MOUNTING:** Custom 12" high x 6" deep alum. raceway to house all electrical - Painted Black - all sides; Raceway mounted to 1/4" steel plate shelf provided at top edge of steel tube using stainless steel fasteners as required; 1" alum. flat bar to be used for back bracing as necessary - painted Black to match raceway
- QUANTITY:** (1) One Channel letterset required for storefront elevation
- CONSTRUCTION NOTES:** ALL SIGNAGE IS REQUIRED TO HAVE EXTERNAL DISCONNECT SWITCHES AS REQUIRED BY NEC

SECTION DETAIL:

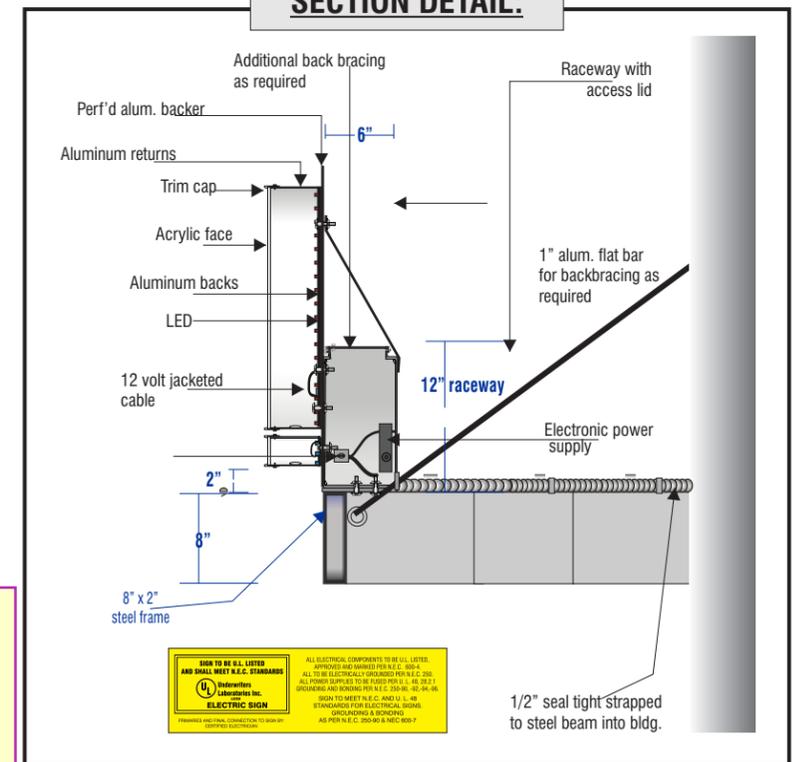

ELECTRICAL NOTE:
ILLINOIS: Any channel letter sets must have seal tie connectors and housings per code

ALL ELECTRICAL COMPONENTS TO BE LISTED APPROVED AND NUMBERED PER N.E.C. 2014. ALL TO BE ELECTRICALLY GROUNDING PER N.E.C. 2014. ALL POWER SUPPLY TO BE LISTED PER N.E.C. 2014. STANDARDS FOR ELECTRICAL SIGNING (CONNECTIONS & WIRING) AS PER N.E.C. 2014 & N.E.C. 600.7

Partner with the best.





www.mcsign.com

CLIENT: THORNTONS

TICKET NO.: 439438

DATE: 02/02/17

PROJECT MANAGER: PHIL SWAN

DESIGNER: KW

ADDRESS: STORE #91709
1101 N. INDEPENDENCE BLVD.
ROMEDEVILLE, IL 60446

PAGE NO.: 3

ELECTRONIC FILE NAME: THORNTONS\2017\IL\VP1709 - ROMEDEVILLE

REVISION HISTORY:

NO.	DESCRIPTION	DATE

CLIENT SIGNATURE:

APPROVAL DATE:



Corporate Office:
8959 Tyler Boulevard
Mentor, Ohio 44060
440-209-6200
800-627-4460



334 Industrial Park Road
Bluefield, Virginia 24605
877-779-9977

LED ILLUMINATED CHANNEL LETTERS

Scale: 3/4" = 1'-0"

15.8 square feet

20 INCH

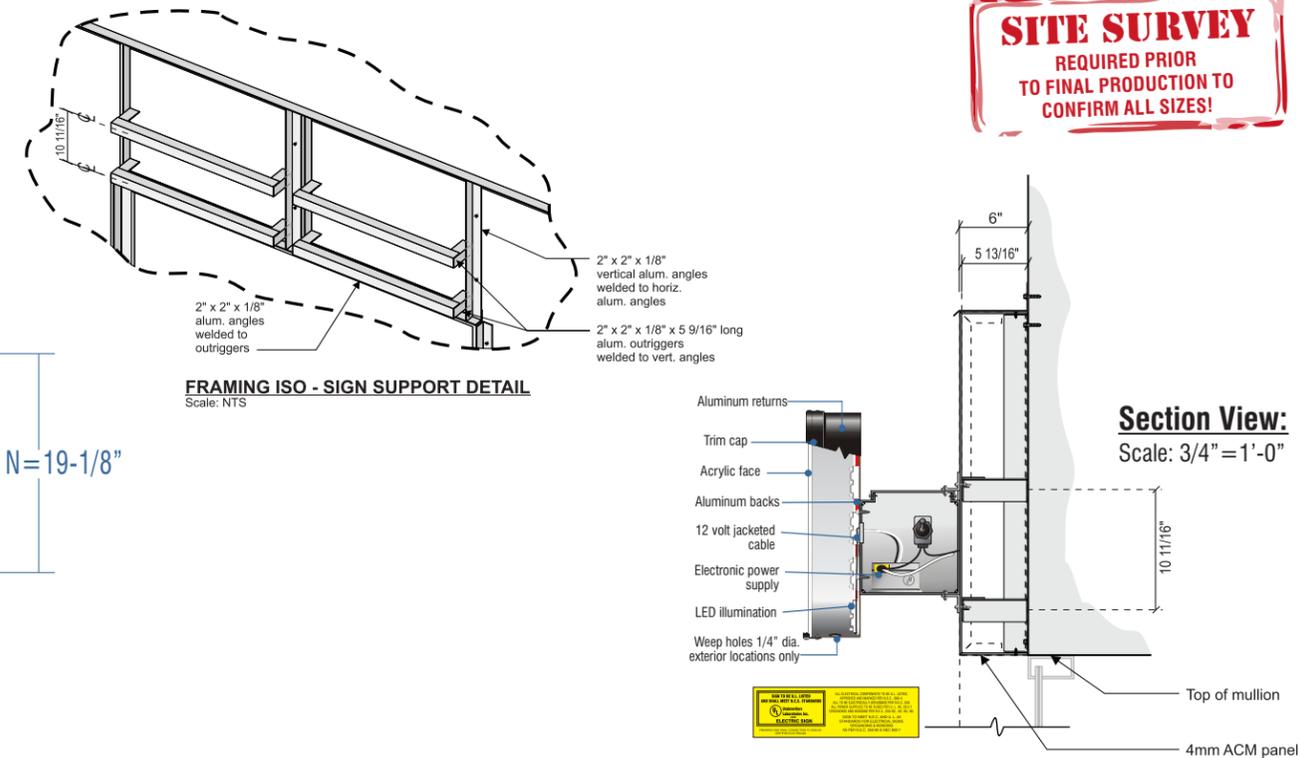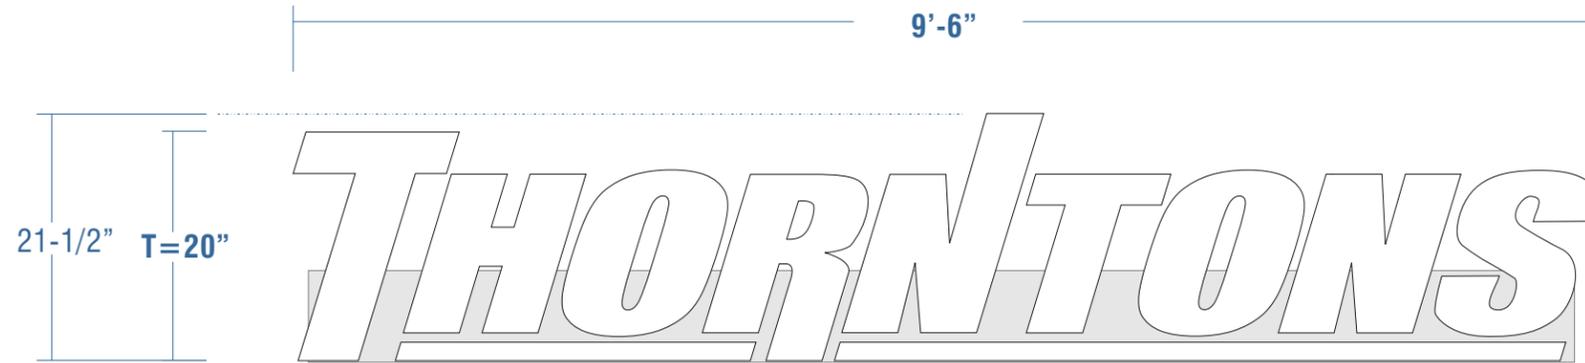

SITE SURVEY
REQUIRED PRIOR
TO FINAL PRODUCTION TO
CONFIRM ALL SIZES!

- FACES:** 3/16" #7328 White acrylic
- TRIMCAP:** 1" White jewelite
- LETTER BACKS:** .063 alum. - prefinish White all sides
- RETURNS:** 5" deep .040 alum. returns painted GG White
- ILLUMINATION:** White LED's as required by manufacturer; Whips to be a minimum of 6'-0" in length
- MOUNTING:** Standard 8" high x 8" deep alum. raceway to house all electrical - Painted to Grip Flex 585 Flame Red match wall surface Raceway to be thru bolted into 2" alum. framework - framework provided by others
- QUANTITY:** (1) One Channel letterset required for rear elevation
- CONSTRUCTION NOTES:** ALL SIGNAGE IS REQUIRED TO HAVE EXTERNAL DISCONNECT SWITCHES AS REQUIRED BY NEC
- MANUFACTURER NOTES:** SIGNAGE MUST BE 3 WIRE


COLOR PALETTE

- #7328 White Acrylic
- Raceway: Gripflex 585 Red

ALL PAINT FINISHES TO BE HIGH GLOSS UNLESS OTHERWISE SPECIFIED!

ELECTRICAL NOTE:
ILLINOIS: Any channel letter sets must have seal tite connectors and housings per code

ENGINEERED DRAWING

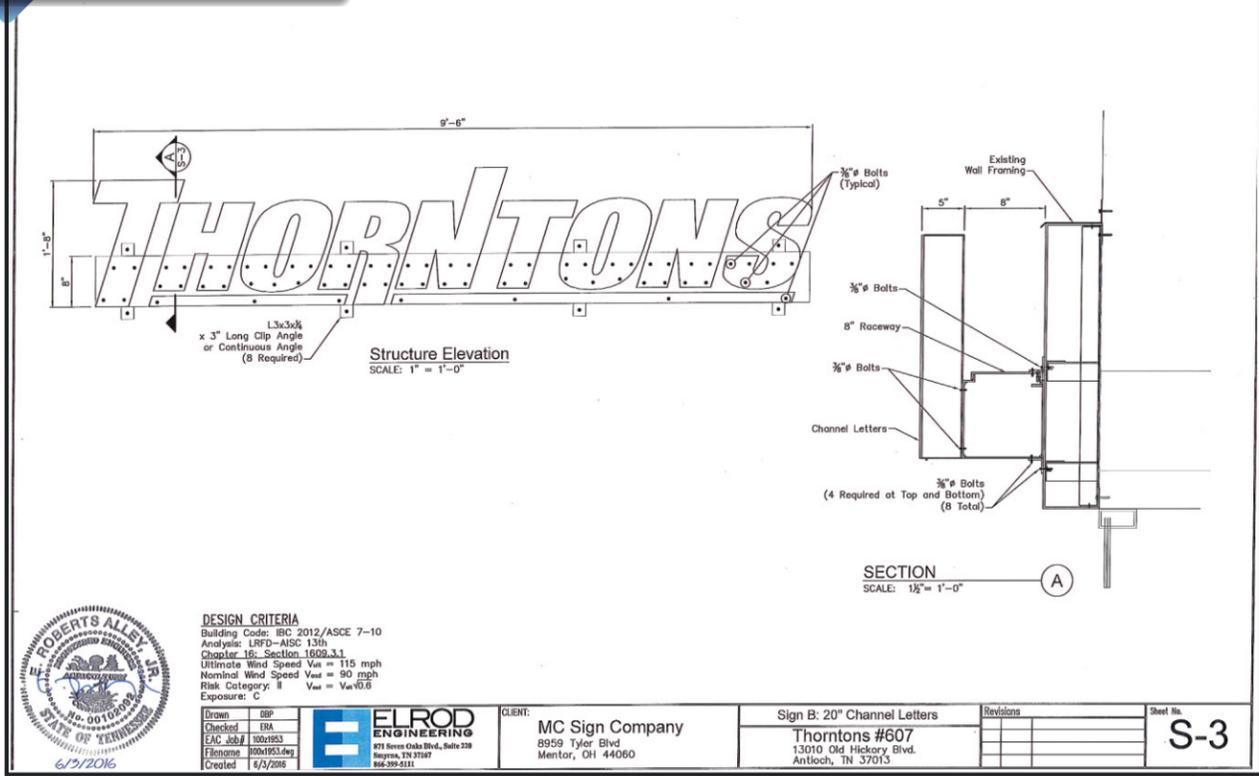

Partner with the best.

www.mcsign.com

CLIENT: THORNTONS

TICKET NO.: 439438

DATE: 10/2/17

PROJECT MANAGER: PHIL SWAN

DESIGNER: SI

ADDRESS: STORE #91709
1101 N. INDEPENDENCE BLVD.
ROMEDEVILLE, IL 60446

PAGE NO.: 4

ELECTRONIC FILE NAME: THORNTONS\2017\IL\P1709 - ROMEDEVILLE

REVISION HISTORY:

10/03/17 KW	Revised to show correct install details

CLIENT SIGNATURE:

APPROVAL DATE:

ELROD ENGINEERING
971 Seven Oaks Blvd., Suite 228
Mentor, TN 37347
916-399-5111

CLIENT: MC Sign Company
8959 Tyler Blvd
Mentor, OH 44060

Sign B: 20" Channel Letters
Thorntons #607
13010 Old Hickory Blvd.
Antioch, TN 37013

Revisions:

Sheet No. S-3

Corporate Office:
8959 Tyler Boulevard
Mentor, Ohio 44060
440-209-6200
800-627-4460

334 Industrial Park Road
Bluefield, Virginia 24605
877-779-9977


NOTE: PRINTS ARE THE EXCLUSIVE PROPERTY OF "MC SIGN COMPANY". ANY UNAUTHORIZED USE OR DUPLICATION WILL RESULT IN A 20% CHARGE PER OCCURRENCE PER THE VALUE OF THE DISPLAY. MC SIGN CO 1998

TYPICAL RETAIL CANOPY ELEVATIONS

Scale: 3/32" = 1'-0"

*TYPICAL CANOPY ELEVATIONS SHOWN FOR VIEWING PURPOSES:
ACTUAL DRAWINGS & DIMENSIONS TO BE PROVIDED*

SITE SURVEY
REQUIRED PRIOR
TO FINAL PRODUCTION TO
CONFIRM ALL SIZES!

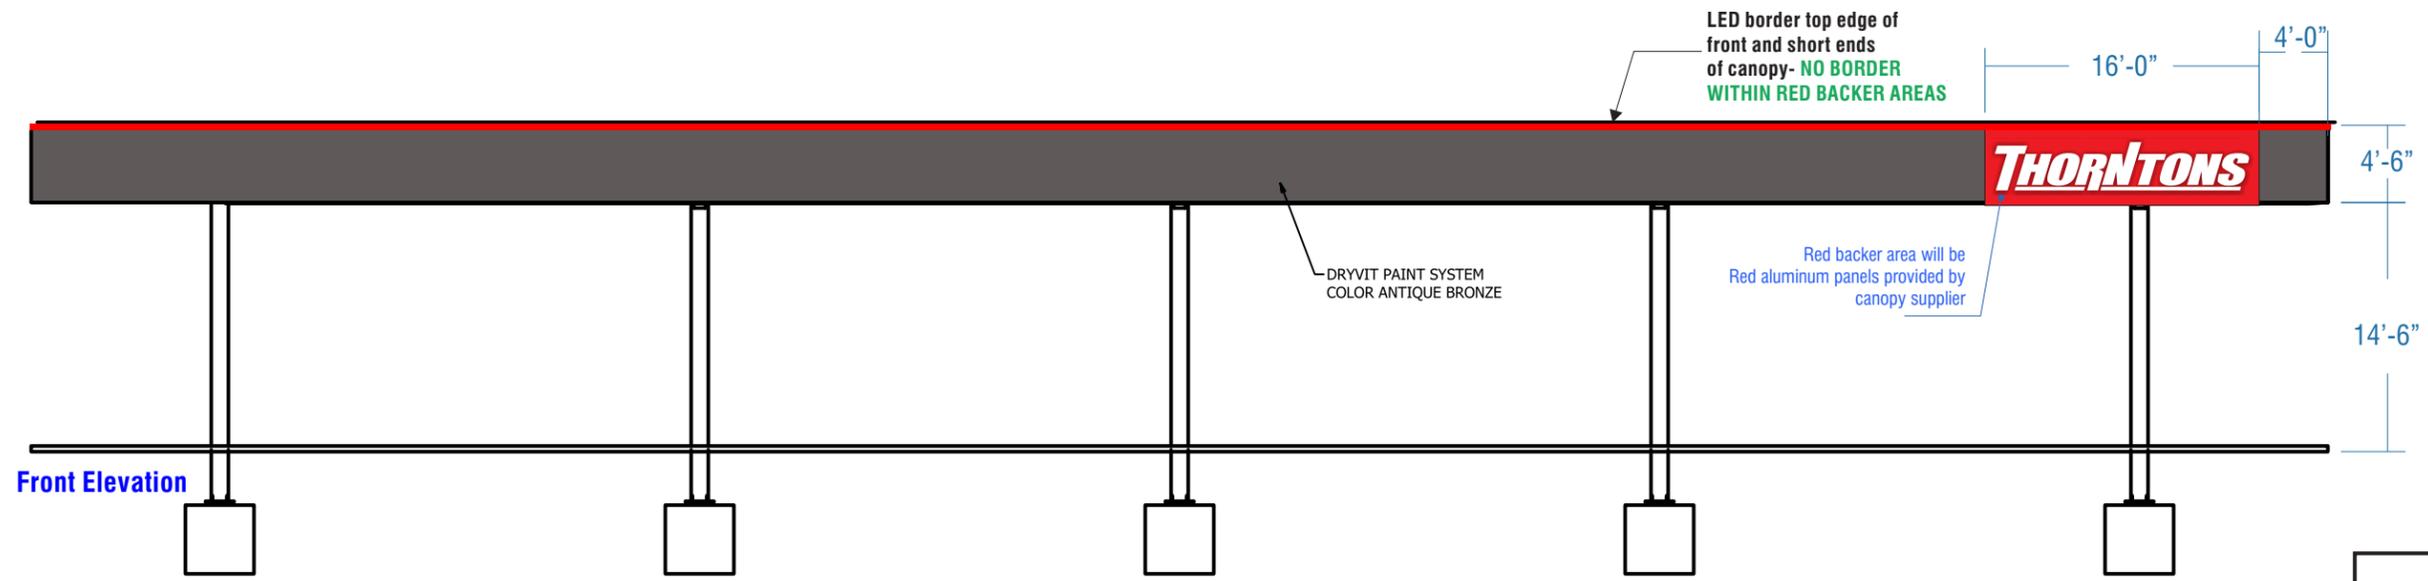


Front Elevation


ELEVATION

COLOR MATCHING


 PMS 8600 C

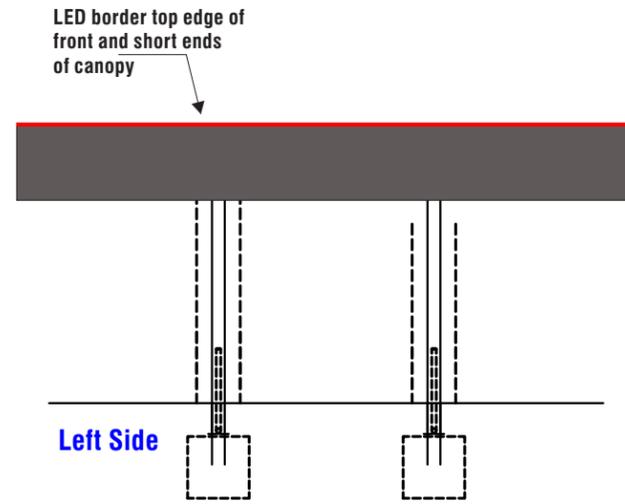

Left Side

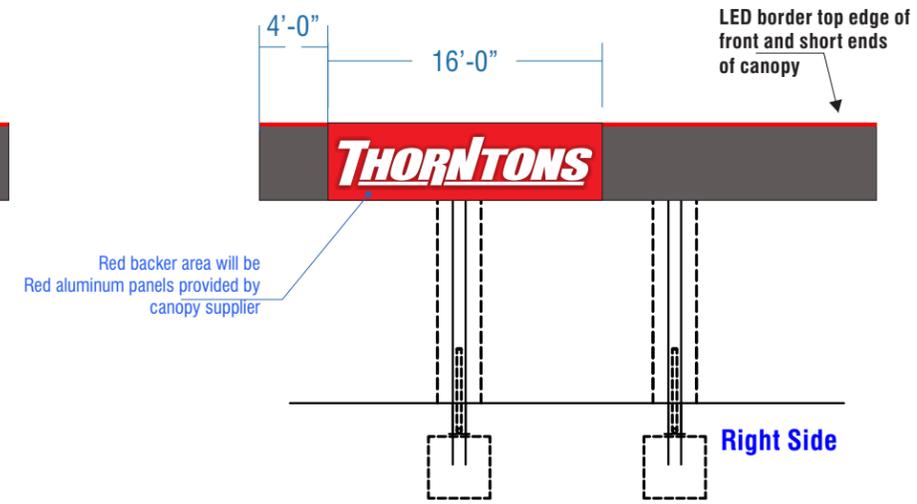

Right Side

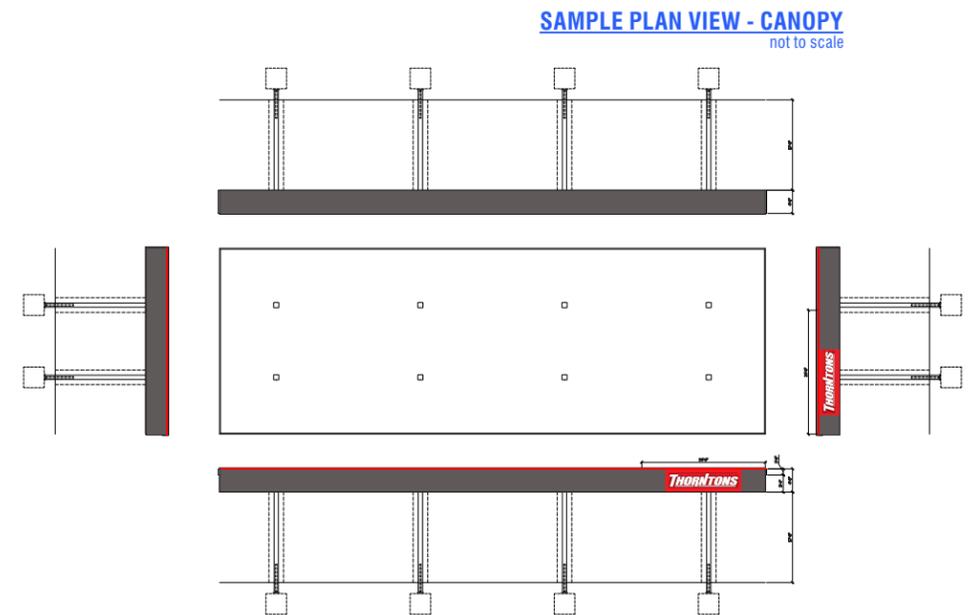

SAMPLE PLAN VIEW - CANOPY
not to scale

Partner with the best.





www.mcsign.com

CLIENT: **THORNTONS**

ADDRESS: STORE #91709
1101 N. INDEPENDENCE BLVD.
ROMEDEVILLE, IL 60446

PAGE NO.: 5

TICKET NO.: 439438

PROJECT MANAGER: PHIL SWAN

ELECTRONIC FILE NAME: THORNTONS\2017\IL\P1709 - ROMEDEVILLE

DATE: 02/02/17

DESIGNER: KW

REVISION HISTORY:

05/16/17 DN	revise sizes
10/19/17 KW	removed signage

CLIENT SIGNATURE: _____

APPROVAL DATE: _____

Corporate Office:
8959 Tyler Boulevard
Mentor, Ohio 44060
440-209-6200
800-627-4460


334 Industrial Park Road
Bluefield, Virginia 24605
877-779-9977

NOTE: PRINTS ARE THE EXCLUSIVE PROPERTY OF "MC SIGN COMPANY". ANY UNAUTHORIZED USE OR DUPLICATION WILL RESULT IN A 20% CHARGE PER OCCURRENCE PER THE VALUE OF THE DISPLAY. MC SIGN CO 1998


TYPICAL DIESEL CANOPY ELEVATIONS
NOT TO SCALE - FOR REFERENCE ONLY

TYPICAL CANOPY VIEW - EXACT MEASUREMENTS OF CANOPY TO BE PROVIDED!


PRESENTATION PURPOSES ONLY
DRAWING NOT INTENDED FOR MANUFACTURING AT THIS TIME!

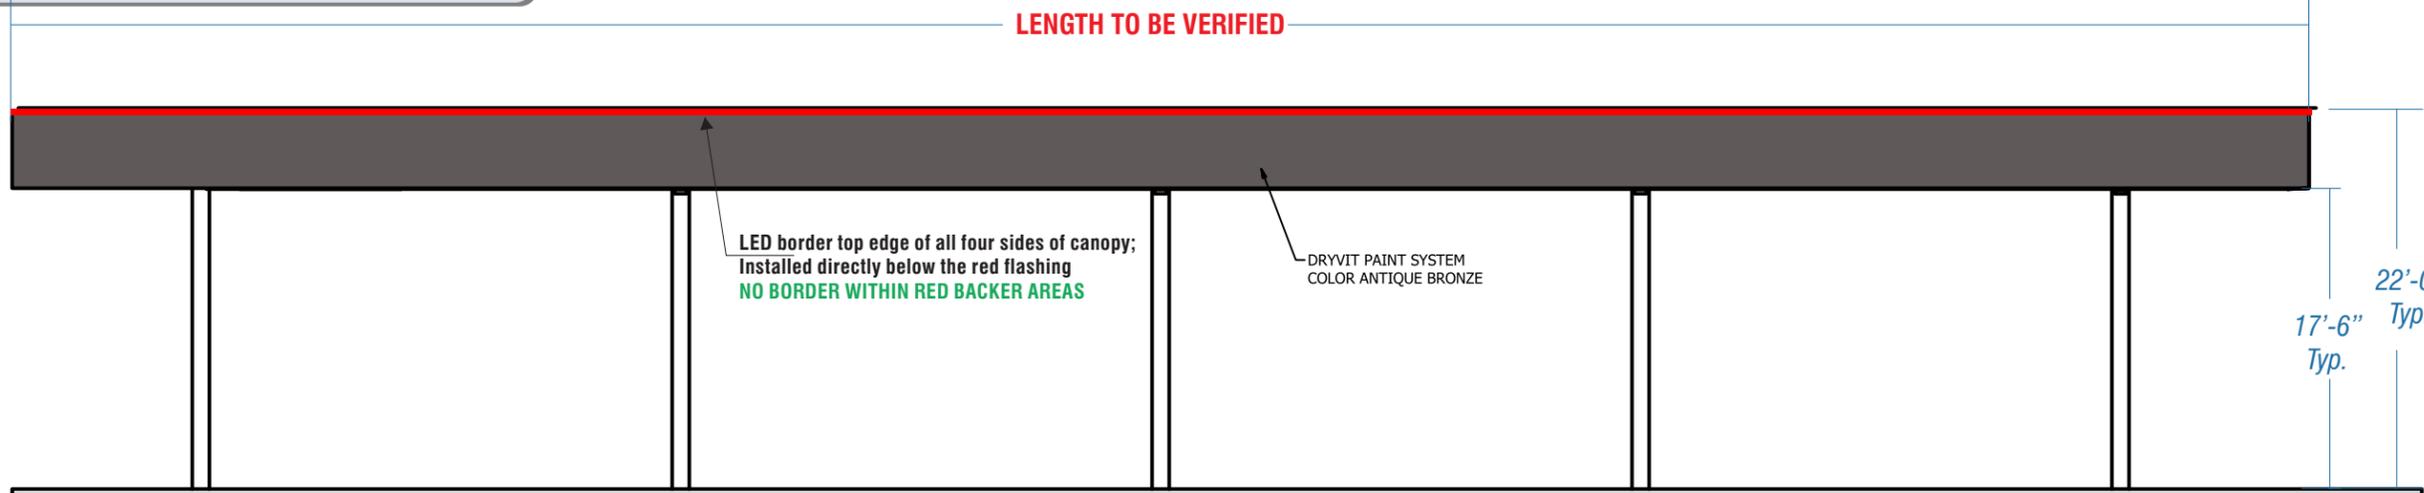

FRONT Elevation

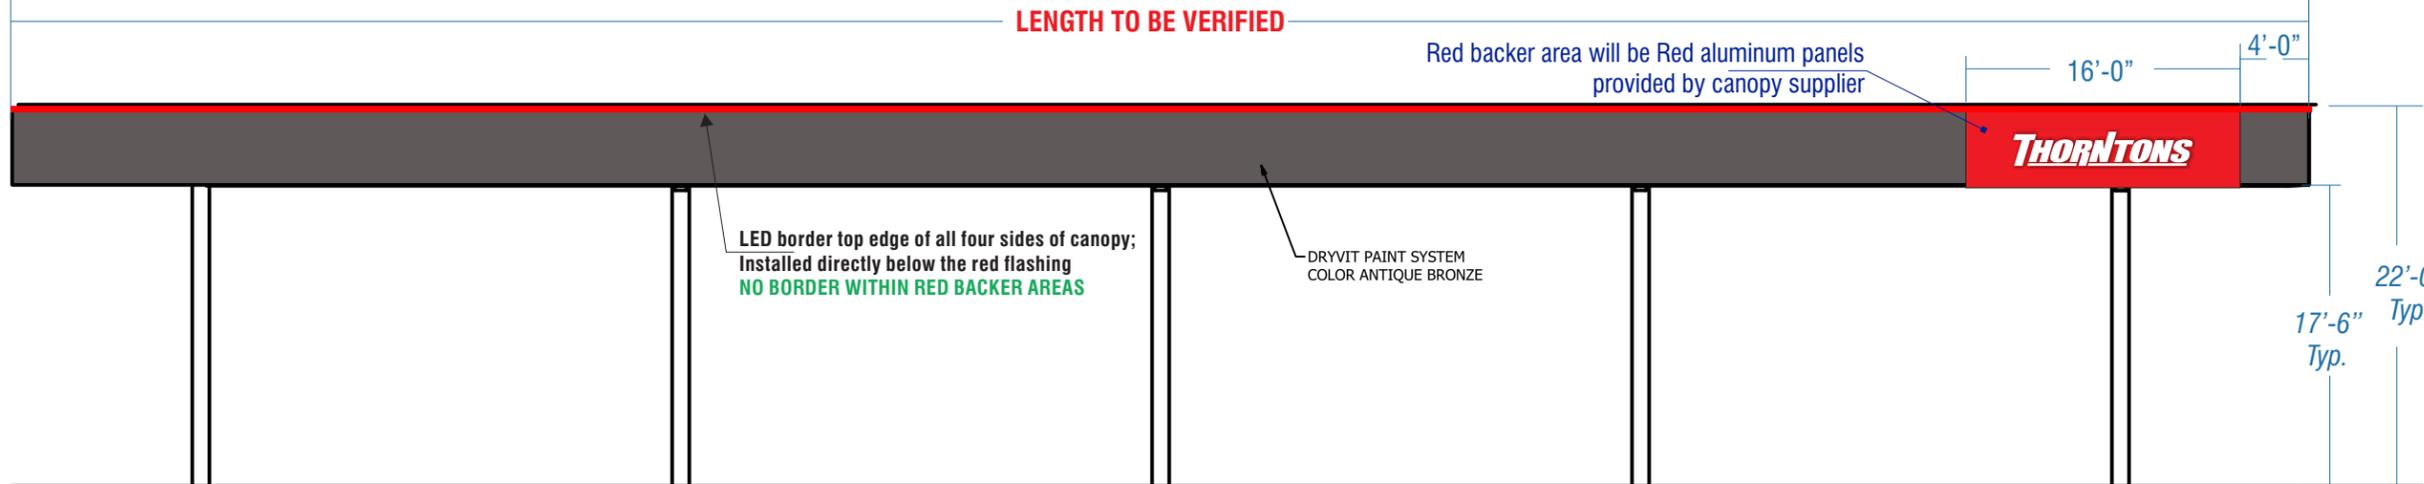

REAR Elevation

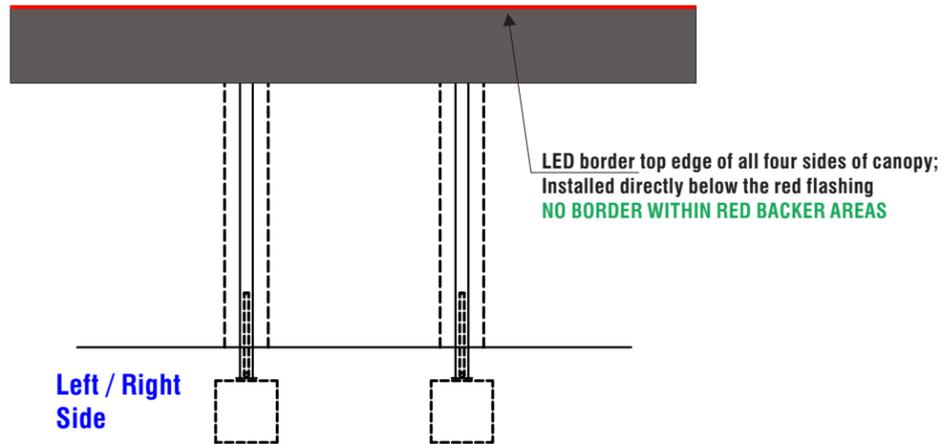


Left / Right Side

COLOR PALETTE

PMS 8600 C

ALL PAINT FINISHES TO BE HIGH GLOSS UNLESS OTHERWISE SPECIFIED!

SAMPLE PLAN VIEW - CANOPY
not to scale

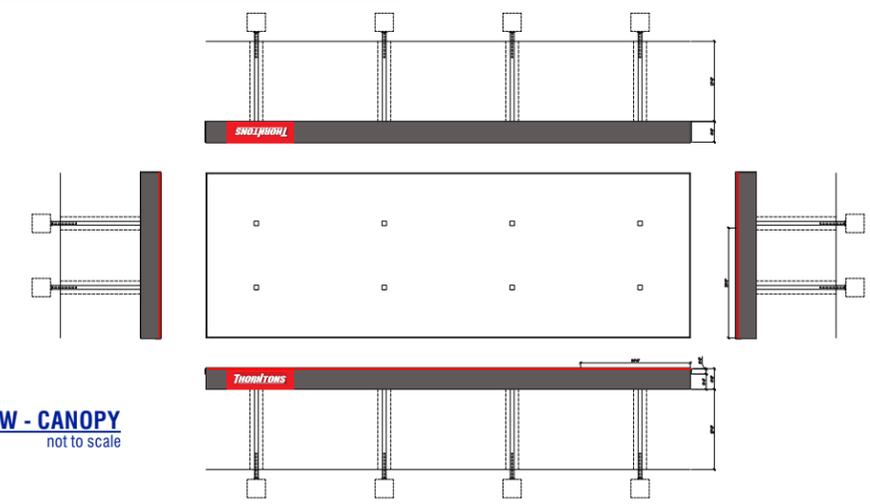

Partner with the best.

www.mcsign.com

CLIENT: **THORNTONS**

ADDRESS: STORE #91709
1101 N. INDEPENDENCE BLVD.
ROMEDEVILLE, IL 60446

PAGE NO.: 6

TICKET NO.: 439438

DATE: 10/10/17

PROJECT MANAGER: PHIL SWAN

DESIGNER: KW

ELECTRONIC FILE NAME: THORNTONS\2017\IL\P1709 - ROMEDEVILLE

REVISION HISTORY:

10/31/17	Viv	Removed signage from South side of Diesel canopy

CLIENT SIGNATURE:

APPROVAL DATE:

Corporate Office:
8959 Tyler Boulevard
Mentor, Ohio 44060
440-209-6200
800-627-4460

334 Industrial Park Road
Bluefield, Virginia 24605
877-779-9977


NOTE: PRINTS ARE THE EXCLUSIVE PROPERTY OF "MC SIGN COMPANY". ANY UNAUTHORIZED USE OR DUPLICATION WILL RESULT IN A 20% CHARGE PER OCCURRENCE PER THE VALUE OF THE DISPLAY. MC SIGN CO 1998

LED ILLUMINATED CHANNEL LETTERS


Scale: 1/2" = 1'-0"

35.5 square feet

30 INCH

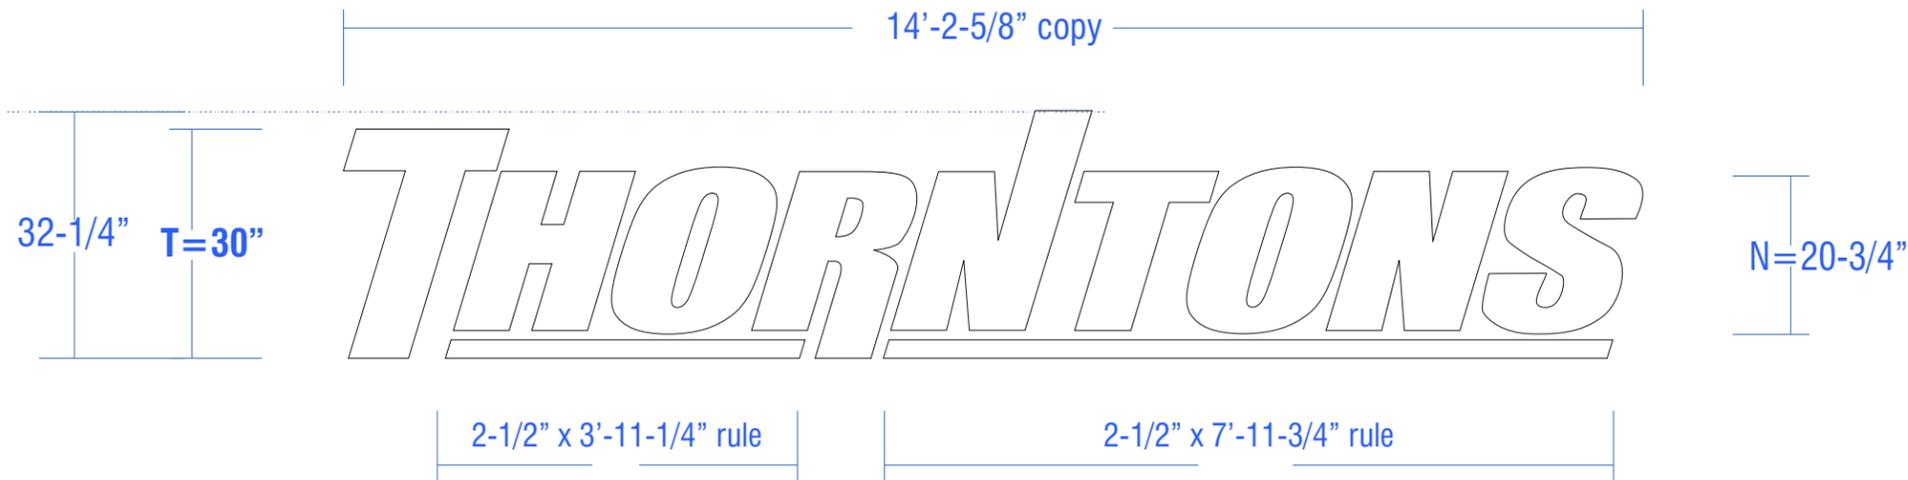


SITE SURVEY
REQUIRED PRIOR
TO FINAL PRODUCTION TO
CONFIRM ALL SIZES!

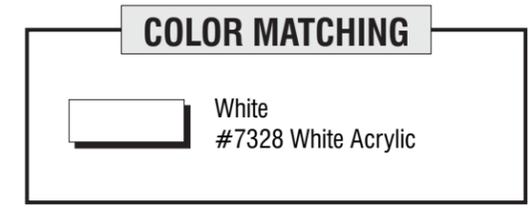

- FACES:** 3/16" #7328 White acrylic
- TRIMCAP:** 1" White jewelite
- LETTER BACKS:** .063 alum. - prefinish White all sides
- RETURNS:** 5" deep .040 alum. returns painted GG White
- ILLUMINATION:** White LED's as required by manufacturer; whips to be a minimum of 6'-0" in length
- MOUNTING:** Flush mounted to canopy sign band as required
- MANUFACTURING NOTE:** Electric feeds need to be in center of letters
- NOTE:** Signage must be 3 wire
- CONSTRUCTION NOTE:** All signage required to have external disconnect switches as required by NEC
- QUANTITY:** RETAIL CANOPY: (2) Two sets required
(1) One for the front of the canopy & (1) One for the right end
DIESEL CANOPY: (1) One set required for North side of canopy

(3) *THREE SETS Total required*

ELECTRICAL NOTE:
ILLINOIS: Any channel letter sets must have seal tite connectors and housings per code

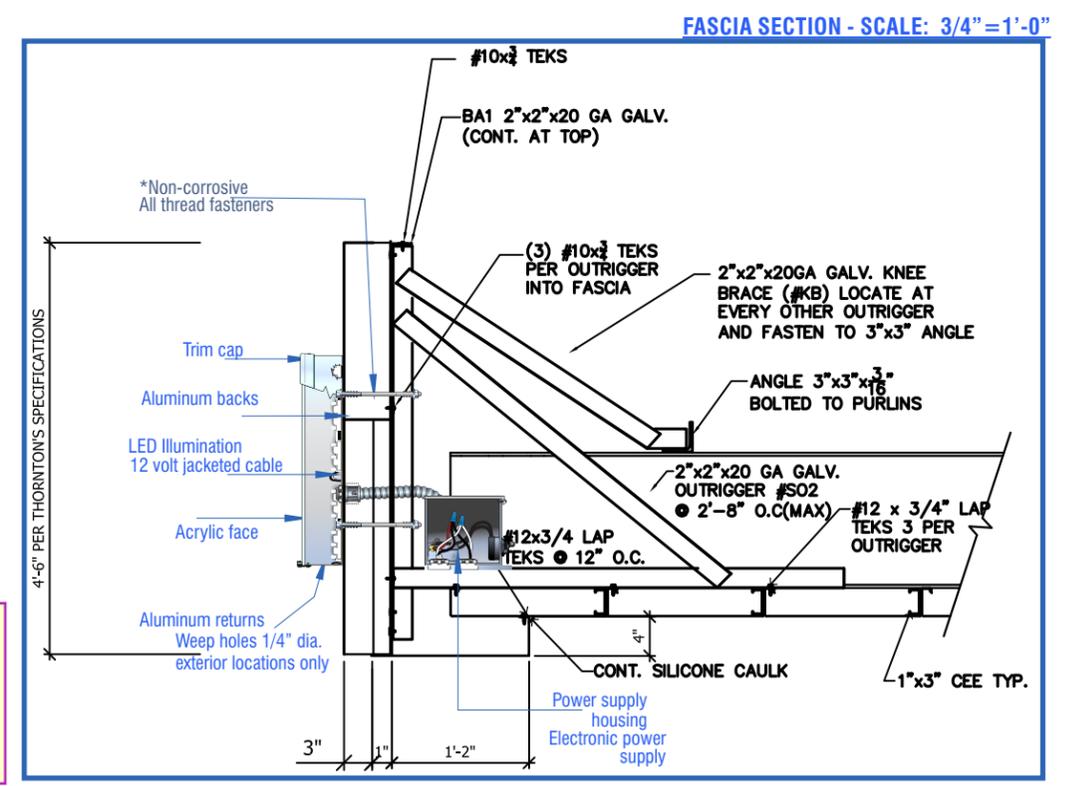

Partner with the best.

www.mcsign.com

CLIENT: **THORNTONS**

TICKET NO.: 439438

DATE: 02/02/17

PROJECT MANAGER: PHIL SWAN

DESIGNER: KW

ADDRESS: STORE #91709
1101 N. INDEPENDENCE BLVD.
ROMEORVILLE, IL 60446

PAGE NO.: 7

ELECTRONIC FILE NAME: THORNTONS\2017\IL\P1709 - ROMEORVILLE

REVISION HISTORY:

05/16/17 DN	revise sizes
10/10/17 KW	revised qty
10/31/17 Viv	Removed signage from South side of Diesel canopy

CLIENT SIGNATURE: _____

APPROVAL DATE: _____

Corporate Office:
8959 Tyler Boulevard
Mentor, Ohio 44060
440-209-6200
800-627-4460

334 Industrial Park Road
Bluefield, Virginia 24605
877-779-9977

NOTE: PRINTS ARE THE EXCLUSIVE PROPERTY OF "MC SIGN COMPANY". ANY UNAUTHORIZED USE OR DUPLICATION WILL RESULT IN A 20% CHARGE PER OCCURRENCE PER THE VALUE OF THE DISPLAY. MC SIGN CO 1998


D/F ILLUM. MONUMENT

Scale: 1/4" = 1'-0"

99.9 square feet

CABINET NOTE:
CABINET MUST INCLUDE LOCKING EXTERNAL DISCONNECT SWITCH IN ILLINOIS & FLORIDA DUE TO CODE REQUIREMENTS

*NOTE: UNLEADED MUST BE STREET SIDE ON BOTH SIDES OF SIGN

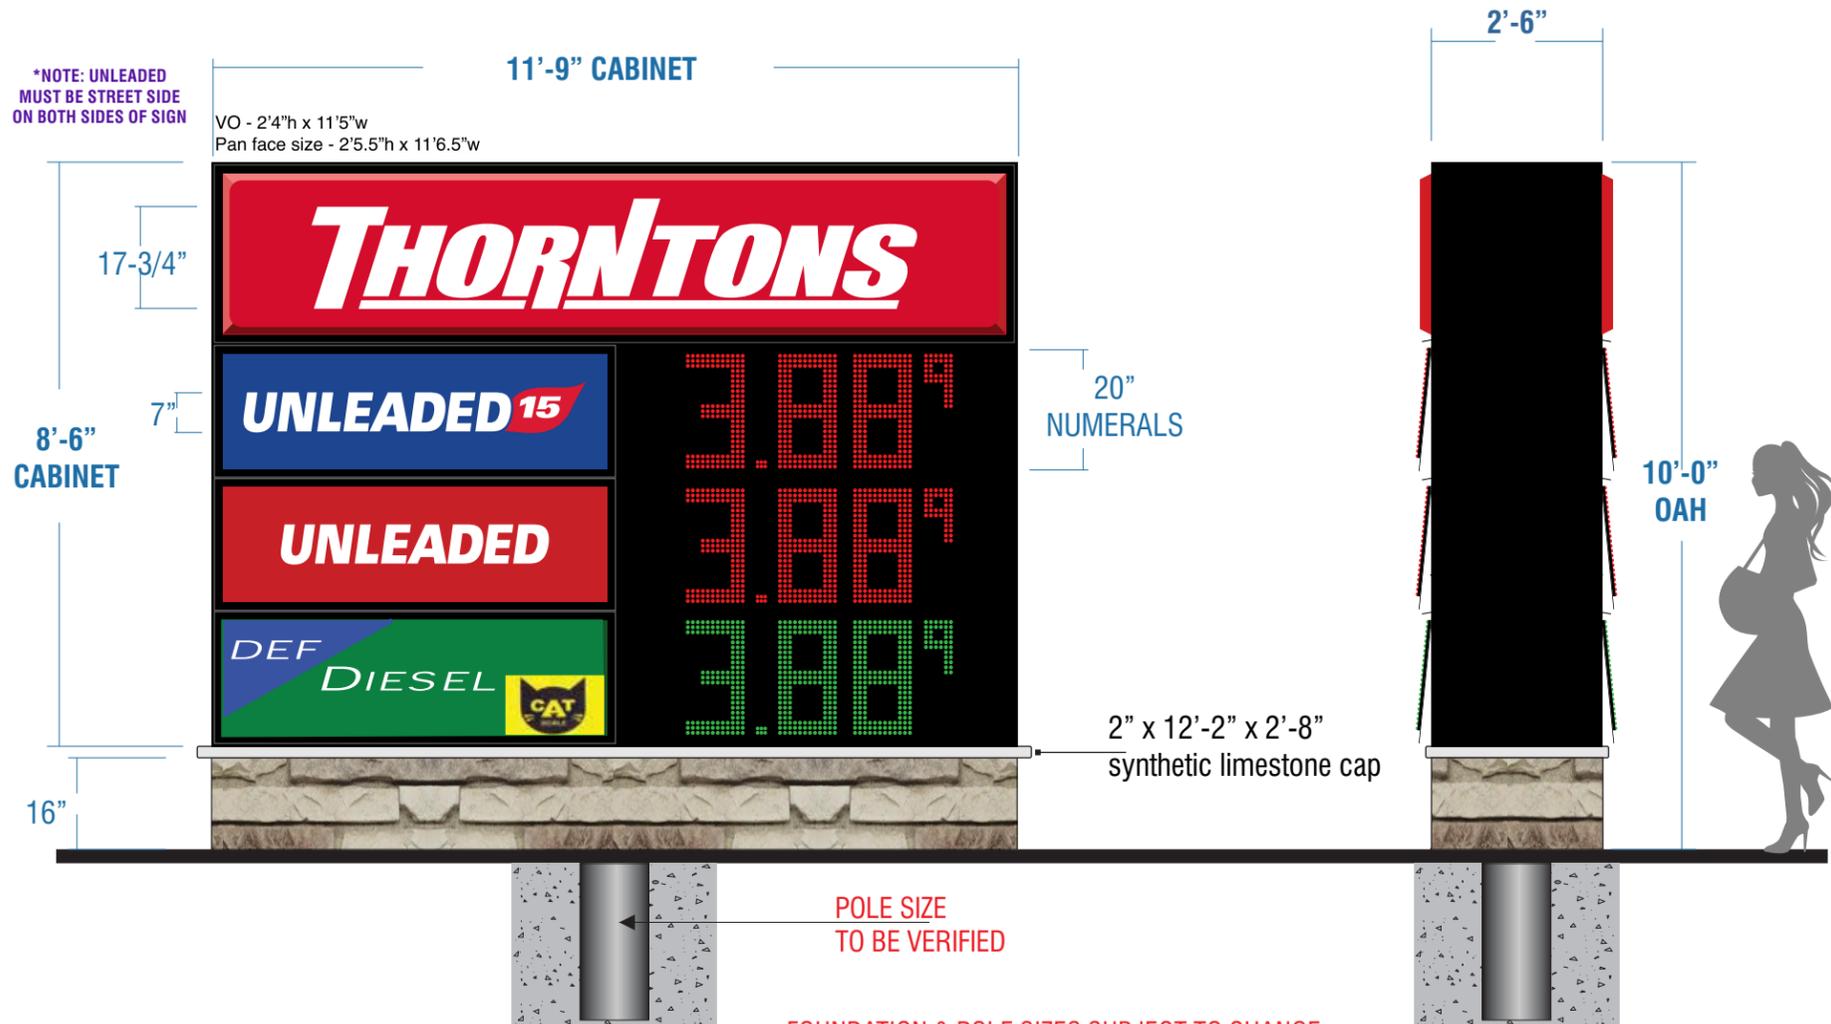

COLOR PALETTE

- Gripflex 585 Flame Red
- UNLEADED 15 & UNLEADED: 3M 3630-33 Red
- DIESEL: 3M 3630-76 Holly Green
- UNLEADED 15: 3M 3630-97 Bristol Blue
- Black

ALL PAINT FINISHES TO BE HIGH GLOSS UNLESS OTHERWISE SPECIFIED!


- CABINET:** 30" DEEP Fab'd alum. construction with 2" retainers & 2" divider bar - All painted Black; Cabinet to sleeve overtop internal support pole & saddle weld into place by installer as required Sign cabinet provided to Thornton's by Sunshine Electronic Displays
- HEADER FACE:** (2) Two gloss panned polycarbonate faces w/ reverse sprayed graphics to match colors shown; *Provided by MC Sign Comp.*
- ILLUM.:** Internal White Sunshine LED lightstrips; **Power supplies to be housed within cabinet**
- PRICING UNIT:** Sunshine double pricer unit - 30" deep Character height = 20"; Red & Green LED digit colors; Commodity panels are flat white polycarbonate panels w/ reverse weeded copy to match colors shown

- BASE:** Fab'd aluminum framework for sign base w/ 3/4" treated plywood overlay *MC Sign to furnish the alum. fab'd frame and plywood wrap the frame* Nichiha Desert Stone veneer installed over framework Stone thickness is approx. 3/4" provided and installed by others; *Stone veneer provided & installed by others*
- CAPS:** (1) One 4" Synthetic limestone cap for top of base *Provided and installed by others following cabinet install;* All Electrical to be done by others - to be connected and tested Installer to connect primary if accessible at time of install.
- SUPPORT:** Cabinet to sleeve overtop internal support; Direct burial installation as required by city requirements & engineering specs **ADDITIONAL FOOTER DETAILS AND POLE SIZE TO FOLLOW**
- JOB NOTES:** GC responsible to layout the sign location based on setback information provided by MC Sign in advance of Sign Spot. Thornton's determines final placement. Sign Spot schedule TBD. Installer to be on site and set up a minimum of (30) thirty minutes prior to scheduled spot. Spot with 4' x 8' plywood piece.

Installer to pour the footer and set the pole immediately following sign spot, within reason.

GC and EC responsible to stub conduit and provide electrical to pricer \ Ensure next to the pole and tall enough to go into the sign following the setting of the footer and pole

Frame and plywood overlay to be installed by installer within a few days of pole setting

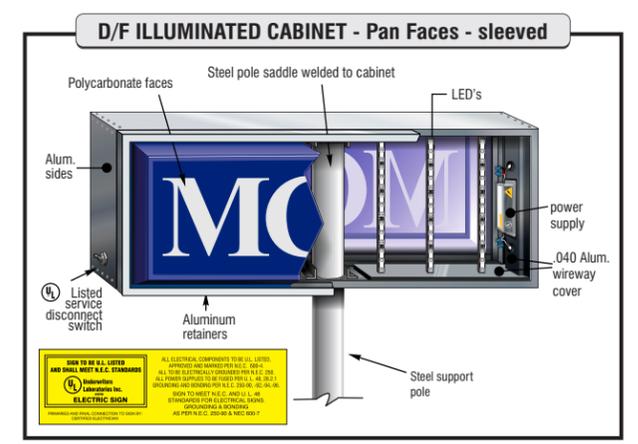

Partner with the best.

www.mcsign.com

CLIENT: THORNTONS

TICKET NO.: 439438

DATE: 02/02/17

PROJECT MANAGER: PHIL SWAN

DESIGNER: KW

ADDRESS: STORE #91709
1101 N. INDEPENDENCE BLVD.
ROMEDEVILLE, IL 60446

PAGE NO.: 8

ELECTRONIC FILE NAME: THORNTONS\2017\IL\P1709 - ROMEDEVILLE

REVISION HISTORY:

04/12/17 TB	Revised Specs to new drawings provided
08/11/17 TB	Revised from Hi-Rise pylon to Monument
9/22/17 SI	Revised to show as 15'-0" OAH

CLIENT SIGNATURE:

APPROVAL DATE:

Corporate Office:
8959 Tyler Boulevard
Mentor, Ohio 44060
440-209-6200
800-627-4460

334 Industrial Park Road
Bluefield, Virginia 24605
877-779-9977


S/F ILLUM. MONUMENT

Scale: 1/4" = 1'-0"

99.9 square feet

CABINET NOTE:
CABINET MUST INCLUDE LOCKING EXTERNAL DISCONNECT SWITCH IN ILLINOIS & FLORIDA DUE TO CODE REQUIREMENTS

*NOTE: UNLEADED MUST BE STREET SIDE ON BOTH SIDIS OF SIGN

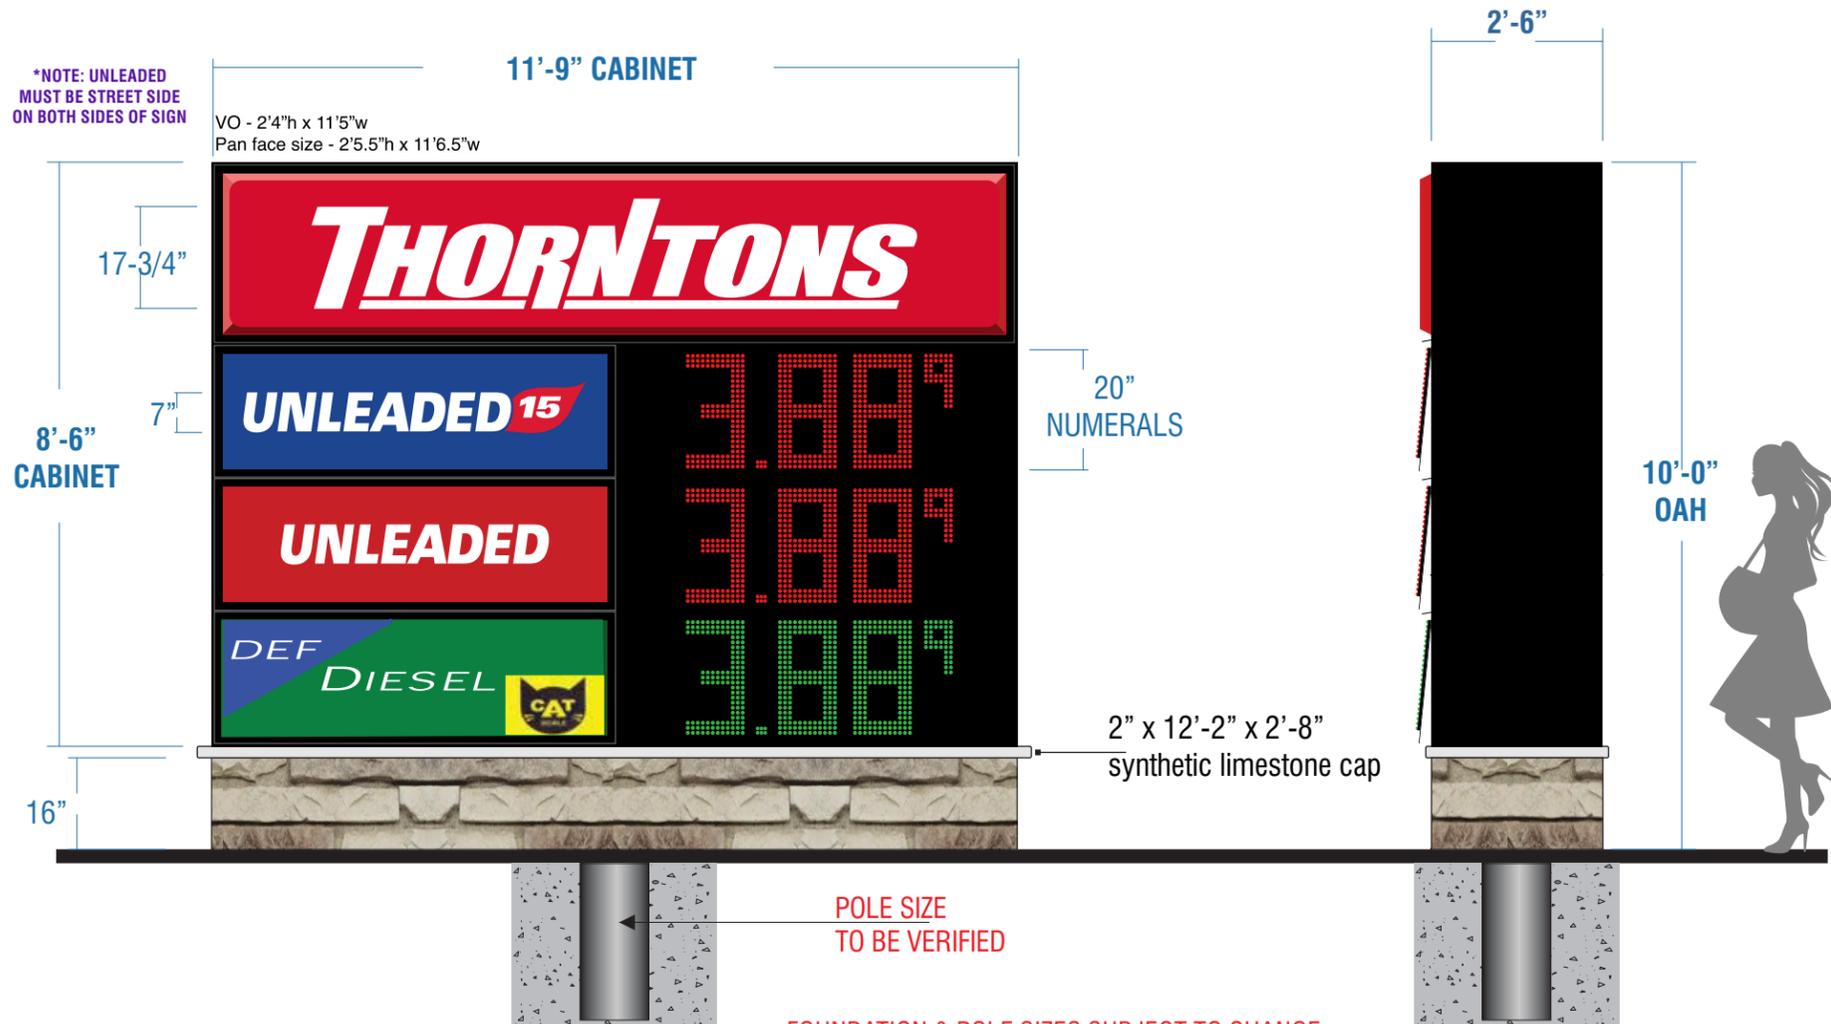

FOUNDATION & POLE SIZES SUBJECT TO CHANGE ACCORDING TO ENGINEERING SPECS & CITY REQUIREMENTS!!

COLOR PALETTE

- Gripflex 585 Flame Red
- UNLEADED 15 & UNLEADED: 3M 3630-33 Red
- DIESEL: 3M 3630-76 Holly Green
- UNLEADED 15: 3M 3630-97 Bristol Blue
- Black

ALL PAINT FINISHES TO BE HIGH GLOSS UNLESS OTHERWISE SPECIFIED!

CABINET: 30" DEEP Fab'd alum. construction with 2" retainers & 2" divider bar; All painted Black; Cabinet to sleeve ovetop internal support pole & saddle weld into place by installer as required
Sign cabinet provided to Thorntons by Sunshine Electronic Displays

HEADER FACE: (1) One gloss panned polycarbonate faces w/ reverse sprayed graphics to match colors shown; *Provided by MC Sign Comp.*

ILLUM.: Internal White Sunshine LED lightstrips; **Power supplies to be housed within cabinet**

PRICING UNIT: Sunshine double pricer unit
Character height = 20"; Red & Green LED digit colors; Commodity panels are flat white polycarbonate panels w/ reverse weeded copy to match colors shown

BASE: Fab'd aluminum framework for sign base w/ 3/4" treated plywood overlay
MC Sign to furnish the alum. fab'd frame and plywood wrap the frame
Nichiha Desert Stone veneer installed over framework
Stone thickness is approx. 3/4" provided and installed by others;
Stone veneer provided & installed by others

CAPS: (1) One 4" Synthetic limestone cap for top of base
Provided and installed by others following cabinet install;
All Electrical to be done by others - to be connected and tested
Installer to connect primary if accessible at time of install.


SUPPORT: Cabinet to sleeve ovetop internal support; Direct burial installation as required by city requirements & engineering specs
ADDITIONAL FOOTER DETAILS TO FOLLOW

JOB NOTES: GC responsible to layout the sign location based on setback information provided by MC Sign in advance of Sign Spot. Thorntons determines final placement. Sign Spot schedule TBD. Installer to be on site and set up a minimum of (30) thirty minutes prior to scheduled spot. Spot with 4' x 8' plywood piece.

Installer to pour the footer and set the pole immediately following sign spot, within reason.

GC and EC responsible to stub conduit and provide electrical to pricer \ Ensure next to the pole and tall enough to go into the sign following the setting of the footer and pole

Frame and plywood overlay to be installed by installer within a few days of pole setting

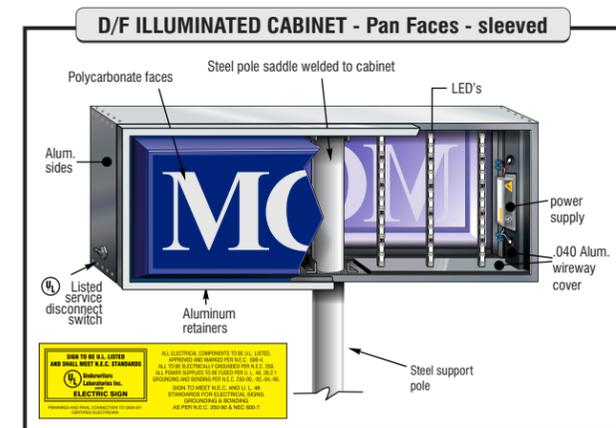

Partner with the best.

www.mcsign.com

CLIENT: THORNTONS

ADDRESS: STORE #91709
1101 N. INDEPENDENCE BLVD.
ROMEDEVILLE, IL 60446

PAGE NO.: 9

TICKET NO.: 439438

DATE: 02/02/17

PROJECT MANAGER: PHIL SWAN

DESIGNER: KW

ELECTRONIC FILE NAME: THORNTONS\2017\IL\1709 - ROMEDEVILLE

REVISION HISTORY:

04/12/17 TB	Revised Specs to new drawings provided
08/11/17 TB	Revised from Hi-Rise pylon to Monument
9/22/17 SI	Revised to show as 15'-0" OAH
10/19/17 KW	Revised to show updated signage
10/31/17 Viv	Updated size and layout for monument

CLIENT SIGNATURE:

APPROVAL DATE:

Corporate Office:
8959 Tyler Boulevard
Mentor, Ohio 44060
440-209-6200
800-627-4460

334 Industrial Park Road
Bluefield, Virginia 24605
877-779-9977



www.mcsign.com

CLIENT: **THORNTONS**
 ADDRESS: STORE #91709
 1101 N. INDEPENDENCE BLVD.
 ROMEOVILLE, IL 60446
 PAGE NO.: 10

TICKET NO.: 439438
 PROJECT MANAGER: PHIL SWAN
 ELECTRONIC FILE NAME: THORNTONS\2017\IL\P1709 - ROMEOVILLE
 DATE: 05/16/17
 DESIGNER: DN

REVISION HISTORY:	
10/19/17 KW	Revised to show updated signage
10/31/17 Viv	revised size of sign

CLIENT SIGNATURE: _____
 APPROVAL DATE: _____



Corporate Office:
 8959 Tyler Boulevard
 Mentor, Ohio 44060
 440-209-6200
 800-627-4460

334 Industrial Park Road
 Bluefield, Virginia 24605
 877-779-9977